

DESIGN AND DEVELOPMENT CONTACTS:

APPLICANT JP MORGAN CHASE BANK, N.A.
1450 BRICKELL AVENUE, 3RD FLOOR
MIAMI, FL 33131
CONTACT: CHRIS FOIT
(786) 473-1769

OWNER NIKOEL LLC.
78 RHODE ISLAND AVENUE #3
NEWPORT, RI 02840

CIVIL ENGINEER CORE STATES, INC.
6060 NORTH CENTRAL EXPRESSWAY, SUITE 850
DALLAS, TX 75206
CONTACT: THOMAS PICKERING, P.E. (MA)
(214) 377-6420

ARCHITECT CORE STATES GROUP
201 S. MAPLE AVE
AMBLER, PA 19002
CONTACT: KEN MACKENZIE, (MA)
(267) 464-8048

SURVEYOR ALLEN & MAJOR ASSOCIATES, INC.
100 COMMERCE WAY
WOBURN, MA 01801-8501
CONTACT: ANDREW RUGGLES
(781) 935-6889

GOVERNING AGENCIES CONTACTS:

PLANNING TOWN OF CONCORD, MASSACHUSETTS
PLANNING DIVISION
CONCORD BUILDING INSPECTIONS, 1ST FLOOR
141 KEYES ROAD
CONCORD, MA 01742
(978) 318-3290

BUILDING DEPARTMENT TOWN OF CONCORD, MASSACHUSETTS
BUILDING AND INSPECTIONS
CONCORD BUILDING INSPECTIONS, 2ND FLOOR
141 KEYES ROAD
CONCORD, MA 01742
(978) 318-3280

FIRE PREVENTION TOWN OF CONCORD, MASSACHUSETTS
FIRE DEPARTMENT
209 WALDEN STREET
CONCORD, MA 01742
(978) 318-3488

UTILITY:

THE FOLLOWING COMPANIES WERE NOTIFIED BY THE MASSACHUSETTS DIG SAFE SYSTEM AND REQUESTED TO MARK OUT UNDERGROUND FACILITIES AFFECTING AND SERVICING THIS SITE. THE UNDERGROUND UTILITY INFORMATION SHOWN HEREON IS BASED UPON THE UTILITY COMPANIES RESPONSE TO THIS REQUEST. REQUEST NUMBER(S): XXXXXXXX

AT&T TRANSMISSION
ZAYO
CENTURY LINK
NATIONAL GRID ELECTRIC & GAS
CONCORD WATER & SEWER DIVISION
VERIZON
COX COMMUNICATIONS INC.

APPLICANT AND OWNER SIGNATURES:

OWNER _____ DATE _____

APPLICANT _____ DATE _____

APPROVAL SIGNATURES:

PLANNING BOARD CHAIRMAN _____ DATE _____

PLANNING BOARD SECRETARY _____ DATE _____


TOWNSHIP ENGINEER _____ DATE _____

PRELIMINARY SITE PLAN APPROVAL

FOR



PROPOSED CHASE BANK 1134 MAIN STREET CONCORD, MA 01742 TOWN OF CONCORD CONCORD, MASSACHUSETTS

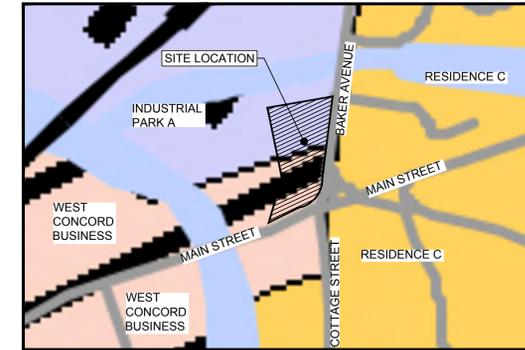

ZONING DISTRICT MAP
1" = 200'



VICINITY MAP
1" = 100'




TAX MAP (3790-1)
1" = 200'

SHEET INDEX			
PAGE NUMBER	DESCRIPTION	PREPARED BY	REVISION NUMBER
CIVIL PLANS			
CV-1	COVER SHEET	CORE STATES	
CV-2	GENERAL NOTES	CORE STATES	
C-1	DEMOLITION PLAN	CORE STATES	
C-2	SITE PLAN	CORE STATES	
C-3	GRADING PLAN	CORE STATES	
C-4	PRE-DEVELOPMENT DRAINAGE PLAN	CORE STATES	
C-5	POST-DEVELOPMENT UTILITY PLAN	CORE STATES	
C-6	WETLAND BUFFER PLAN	CORE STATES	
C-7	LIGHTING PLAN	CORE STATES	
C-8	LIGHTING DETAILS	CORE STATES	
LP-1	LANDSCAPE PLANTING	EVERGREEN	
LP-2	PLANTING DETAILS & SPECS	EVERGREEN	
CD-1	EROSION CONTROL DETAILS	CORE STATES	
CD-2	EROSION CONTROL DETAILS	CORE STATES	
CD-3	EROSION CONTROL DETAILS	CORE STATES	
CD-4	CONSTRUCTION DETAILS	CORE STATES	
CD-5	CONSTRUCTION DETAILS	CORE STATES	
CD-6	CONSTRUCTION DETAILS	CORE STATES	
CD-7	STORM DETAILS	CORE STATES	
CD-8	SIGNAGE DETAILS	CORE STATES	
ALTA/ACSM LAND TITLE SURVEY		ALLEN & MAJOR	
A1.1.1	PROPOSED FLOOR PLAN	CORE STATES	
A2.1	PROPOSED NORTH & EAST EXTERIOR ELEVATIONS	CORE STATES	
A2.2	PROPOSED SOUTH & WEST EXTERIOR ELEVATIONS	CORE STATES	

ALERT TO CONTRACTOR:

1. THE SITE WORK FOR THE PROPOSED DEVELOPMENT SHALL MEET OR EXCEED ALL CITY AND/OR COUNTY AND STATE STANDARDS FOR SITE WORK.
2. ALL NECESSARY INSPECTIONS AND/OR CERTIFICATIONS REQUIRED BY THE TOWN OF SMITHFIELD CODES, TOWN OF SMITHFIELD AND/OR UTILITY SERVICE COMPANIES SHALL BE PERFORMED PRIOR TO ANNOUNCED BUILDING POSSESSION AND THE FINAL CONNECTION OF SERVICES.

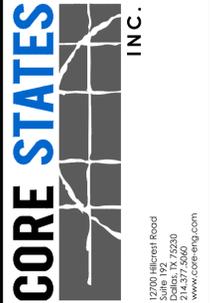

DOCUMENTS PREPARED BY CORE STATES, INC., INCLUDING THIS DOCUMENT ARE TO BE USED ONLY FOR THE SPECIFIC PROJECT AND SPECIFIC USE FOR WHICH THEY WERE INTENDED. ANY EXTENSION OF USE TO ANY OTHER PROJECTS, BY OWNER OR BY ANY OTHER PARTY, WITHOUT THE EXPRESSED WRITTEN CONSENT OF CORE STATES, INC. IS DONE UNLAWFULLY AND AT THE USER'S OWN RISK. IT IS USED IN A WAY OTHER THAN THAT SPECIFICALLY INTENDED. USER WILL HOLD CORE STATES, INC. HARMLESS FROM ALL CLAIMS AND LOSSES.

CLIENT



Know what's below. Call before you dig.

REV	DATE	COMMENT	BY
1	06/01/20	REVISED PER TOWNSHIP COMMENTS	KGF

DOCUMENT
SITE PLAN
APPROVAL FOR
CHASE BANK

SITE LOCATION
MAIN STREET &
BAKER AVENUE
1134 MAIN STREET
CONCORD, MA 01742

ENGINEER SEAL

ALAN D. ROSCOE, P.E.
MA LICENSE #40163
SHEET TITLE
COVER
SHEET

JOB #: JPM-27599
DATE: 04/28/2020
SCALE: AS SHOWN
DRAWN BY: CC
CHECKED BY: TP

SHEET NO.
CV-1

GENERAL SITE NOTES

- 1. ALL CONSTRUCTION MATERIALS AND TECHNIQUES OF INSTALLATION SHALL MEET PERFORMANCE VALUES OF THE MATERIALS SPECIFIED AND COMPLY WITH ALL TOWNSHIP/COUNTY REGULATIONS AND CODES AND O.S.H.A. STANDARDS.
2. THE GENERAL CONTRACTOR SHALL BE RESPONSIBLE FOR ENSURING THAT THIS PROJECT IS CONSTRUCTED IN ACCORDANCE WITH THESE DOCUMENTS AND IN COMPLIANCE WITH CODES INDICATED HEREIN.
3. ALL MATERIALS ARE TO BE INSTALLED IN ACCORDANCE WITH MANUFACTURER'S REQUIREMENTS.
4. ALL CONDITIONS SHOWN TO BE "EXISTING" SHALL BE VERIFIED IN THE FIELD BY THE GENERAL CONTRACTOR PRIOR TO START OF CONSTRUCTION.
5. CONTRACTOR TO REVIEW AND FOLLOW CONSTRUCTION TECHNIQUES/SPECIFICATIONS OUTLINED IN THE SITE GEOTECHNICAL REPORT.
6. THE GENERAL CONTRACTOR SHALL BE RESPONSIBLE FOR HAVING A THOROUGH KNOWLEDGE OF EXISTING FIELD CONDITIONS AND OF ALL DRAWINGS AND SPECIFICATIONS RELATED TO THEIR FIELD.
7. THE GENERAL CONTRACTOR SHALL BE RESPONSIBLE FOR ENSURING THE SAFETY OF ALL PERSONS ON THE JOB SITE AT ALL TIMES INCLUDING (BUT NOT LIMITED TO) SUBCONTRACTORS, FACILITY EMPLOYEES, VENDORS, DESIGN STAFF PROFESSIONALS AND INSPECTION PERSONNEL.
8. THE GENERAL CONTRACTOR SHALL PROVIDE DUMPSTERS, PORTABLE TOILETS AND TEMPORARY POWER FOR UNRESTRICTED PROJECT RELATED USE BY OTHERS FOR THE DURATION OF THE PROJECT.
9. THE GENERAL CONTRACTOR SHALL COORDINATE PROJECT PHASING AND STORAGE OF MATERIALS WITH THE OWNER.
10. THE GENERAL CONTRACTOR IS RESPONSIBLE FOR RECEIVING, UNLOADING, STORING AND PROTECTING OF MATERIALS AND EQUIPMENT SUPPLIED BY THE OWNER UNTIL IT HAS BEEN INSTALLED AND ACCEPTED BY THE OWNER.
11. THE GENERAL CONTRACTOR SHALL BE RESPONSIBLE FOR KEEPING THE AREA CLEAN AND FREE OF DEBRIS AT ALL TIMES DURING CONSTRUCTION.
12. EXISTING PAVING THAT WILL REMAIN AFTER CONSTRUCTION SHALL BE PROTECTED FROM DAMAGE.
13. THE GENERAL CONTRACTOR SHALL FIELD VERIFY THE EXACT LOCATION OF ALL PUBLIC AND PRIVATE UTILITIES.
14. SAWCUT AND REMOVE PORTIONS OF EXISTING PAVING ONLY AS REQUIRED TO INSTALL NEW UTILITIES OR TO CONSTRUCT PROPOSED FACILITIES PER THIS PLAN.
15. PROVIDE TEMPORARY CHAIN LINK FENCING, MINIMUM 6'-0" HIGH, AROUND ENTIRE AREA OF CONSTRUCTION.
16. ALL DIMENSIONS AND RADII ARE TO FACE OF CURB UNLESS OTHERWISE NOTED.
17. CONTRACTOR IS RESPONSIBLE FOR PROTECTION OF ALL PROPERTY CORNERS.
18. CONTRACTOR SHALL MATCH PROPOSED CURB AND GUTTER, CONCRETE, AND PAVEMENT TO EXISTING IN GRADE AND ALIGNMENT.
19. CONSTRUCTION SHALL COMPLY WITH ALL GOVERNING CODES AND BE CONSTRUCTED TO SAME.
20. CONTRACTOR IS RESPONSIBLE FOR REPAIRING THE DAMAGE DONE TO ANY EXISTING ITEM TO REMAIN DURING CONSTRUCTION.
21. CONTRACTOR SHALL REFER TO THE ARCHITECTURAL PLANS FOR EXACT LOCATIONS AND DIMENSIONS OF ALL CURBS, BENCHMARKS, STAIRS, RAMPS, SLOPE PAVING, SIDEWALKS, PRECISE BUILDING DIMENSIONS AND EXACT BUILDING UTILITY ENTRANCE LOCATIONS.
22. ALL DISTURBED AREAS ARE TO RECEIVE FOUR INCHES OF TOPSOIL, SEED OR SOD, MULCH AND WATER UNTIL A HEALTHY STAND OF GRASS IS ESTABLISHED.
23. EXISTING STRUCTURES WITHIN CONSTRUCTION LIMITS ARE TO BE ABANDONED, REMOVED OR RELOCATED AS NECESSARY.
24. CONTRACTOR SHALL BE RESPONSIBLE FOR ALL RELOCATIONS, (UNLESS OTHERWISE NOTED ON PLANS) INCLUDING BUT NOT LIMITED TO, ALL UTILITIES, STORM DRAINAGE, SIGNS, TRAFFIC SIGNALS & POLES, ETC. AS REQUIRED.
25. THE SITE WORK FOR THIS PROJECT SHALL MEET OR EXCEED THE SPECIFICATIONS IN THE CONTRACT DOCUMENTS.
26. ANY DISCREPANCIES ON THE DRAWINGS SHALL BE IMMEDIATELY BROUGHT TO THE ATTENTION OF THE OWNER AND ENGINEER OF RECORD BEFORE COMMENCING WORK.
27. IN THE EVENT THE CONSTRUCTION IS ABANDONED PRIOR TO THE COMPLETION OF THE PROJECT, ALL CONSTRUCTION AND STOCKPILED VEGETATIVE DEBRIS AND FILL WILL BE REMOVED FROM THE SITE AND THE SITE WILL BE STABILIZED PER RIPDES GENERIC PERMIT FOR STORM WATER DISCHARGE FROM LARGE AND SMALL CONSTRUCTION ACTIVITIES.
28. THESE PLANS ARE INTENDED TO AND SHALL COMPLY WITH AMERICANS WITH DISABILITIES ACT AND THE MASSACHUSETTS ACCESSIBILITY CODES.
29. ALL VEGETATION FROM CLEARING AND GRUBBING WILL BE DISPOSED OF OFF-SITE.
30. CONTRACTOR IS RESPONSIBLE FOR PERMITTING, INSTALLATION AND MAINTENANCE OF ALL MAINTENANCE OF TRAFFIC OPERATIONS DURING CONSTRUCTION.
31. ALL DESIGN AND CONSTRUCTION MUST CONFORM TO THE MINIMUM STANDARDS SET DOWN IN THE TOWNSHIP/COUNTY DEVELOPMENT CODE, ZONING, AND/OR RELATED ORDINANCES, AND MINIMUM TESTING FREQUENCY REQUIREMENTS.

GENERAL UTILITY NOTES

- 1. CONTRACTOR SHALL COORDINATE ANY DISRUPTIONS TO EXISTING UTILITY SERVICES WITH ADJACENT PROPERTY OWNERS.
2. ALL ELECTRIC, TELEPHONE AND GAS EXTENSIONS INCLUDING SERVICE LINES SHALL BE CONSTRUCTED TO THE APPROPRIATE UTILITY COMPANY SPECIFICATIONS.
3. CONSTRUCTION SHALL NOT START ON ANY PUBLIC UTILITY SYSTEM UNTIL WRITTEN APPROVAL HAS BEEN RECEIVED BY THE ENGINEER FROM THE APPROPRIATE GOVERNING AUTHORITY AND CONTRACTOR HAS BEEN NOTIFIED BY SAID ENGINEER BY ENGINEER.
4. PRIOR TO THE CONSTRUCTION OF OR CONNECTION TO ANY STORM DRAIN, SANITARY SEWER, WATER MAIN OR ANY OF THE DRY UTILITIES, THE CONTRACTOR SHALL EXCAVATE, VERIFY AND CALCULATE ALL POINTS OF CONNECTION AND ALL UTILITY CROSSINGS AND INFORM THE ENGINEER AND THE OWNER/DEVELOPER OF ANY CONFLICT OR REQUIRED DEVIATIONS FROM THE PLAN.
5. PRIOR TO CONSTRUCTION, THE GENERAL CONTRACTOR SHALL VERIFY THAT "STUB OUTS" FOR POWER, TELEPHONE, FIBER OPTICS, WATER AND SEWER (IF APPLICABLE) HAVE BEEN PROVIDED BY OTHERS (IF APPLICABLE) AT THE AREA ADJACENT TO THE PROPOSED BUILDING.
6. THE GENERAL CONTRACTOR SHALL BE RESPONSIBLE FOR COORDINATING THE SCHEDULE FOR INSTALLATION WITH THE UTILITY COMPANIES AND THE OWNER.
7. IF ANY EXISTING STRUCTURES TO REMAIN ARE DAMAGED DURING CONSTRUCTION, IT SHALL BE THE CONTRACTOR'S RESPONSIBILITY TO REPAIR AND/OR REPLACE THE EXISTING STRUCTURE AS NECESSARY TO RETURN IT TO EXISTING CONDITIONS OR BETTER.
8. ALL SANITARY SEWER MANHOLES IN PAVED AREAS SHALL BE FLUSH WITH PAVEMENT, AND SHALL HAVE TRAFFIC BEARING RINGS & COVERS.
9. ALL FILL MATERIAL IS TO BE IN PLACE, AND COMPACTED BEFORE INSTALLATION OF PROPOSED UTILITIES.
10. CONTRACTOR SHALL NOTIFY THE UTILITY AUTHORITIES INSPECTORS 72 HOURS BEFORE CONNECTING TO ANY EXISTING LINE.
11. UNDERGROUND UTILITY LINES SHALL BE INSTALLED, INSPECTED AND APPROVED BEFORE BACKFILLING.
12. REFER TO ARCHITECTURAL DRAWINGS FOR TIE-IN OF ALL UTILITIES.
13. CONTRACTOR IS RESPONSIBLE FOR COMPLYING TO THE SPECIFICATIONS OF THE LOCAL AUTHORITIES WITH REGARDS TO MATERIALS AND INSTALLATION OF THE WATER AND SEWER LINES.
14. CONTRACTOR SHALL COORDINATE WITH ALL UTILITY COMPANIES FOR INSTALLATION REQUIREMENTS AND SPECIFICATIONS.
15. DRAWINGS DO NOT PURPORT TO SHOW ALL EXISTING UTILITIES.
16. EXISTING UTILITIES SHALL BE VERIFIED IN FIELD PRIOR TO INSTALLATION OF ANY NEW LINES.
17. THE CONTRACTOR SHALL CONSTRUCT GRAVITY SEWER LATERALS, MANHOLES, GRAVITY SEWER LINES AND DOMESTIC WATER AND FIRE PROTECTION SYSTEM AS SHOWN ON THESE PLANS.
18. THE CONTRACTOR SHALL RESTORE ALL DISTURBED VEGETATION IN KIND, UNLESS SHOWN OTHERWISE.
19. DEFLECTION OF PIPE JOINTS AND CURVATURE OF PIPE SHALL NOT EXCEED THE MANUFACTURER'S SPECIFICATIONS.
20. ALL UTILITY AND STORM DRAIN TRENCHES LOCATED UNDER AREAS TO RECEIVE PAVING SHALL BE COMPLETELY BACKFILLED AND COMPACTED IN ACCORDANCE WITH SPECIFICATIONS.
21. SHOP DRAWINGS FOR ALL MATERIALS AND APPURTENANCE SHALL BE SUBMITTED TO AND APPROVED BY THE GOVERNING UTILITY DEPARTMENT.
22. AT LEAST THREE WEEKS PRIOR TO CONSTRUCTION, THE CONTRACTOR SHALL NOTIFY THE TOWNSHIP/COUNTY AND THE UTILITY COMPANY AND SUPPLY THEM WITH ALL REQUIRED SHOP DRAWINGS.
23. THE CONTRACTOR SHALL BE RESPONSIBLE FOR LOCATING EXISTING WATER MAINS, FORCE MAINS, SANITARY SEWER AND STORM MAINS AND MAINTAIN A MINIMUM CLEARANCE BETWEEN WATER MAINS AND OTHER UTILITIES AT ALL POINTS ALONG THEIR LENGTH AS REQUIRED IN THE PLANS, DETAILS, AND SPECIFICATIONS.
24. SANITARY SEWER, FORCE MAINS, SEWER LATERALS, AND STORM SEWERS SHOULD CROSS UNDER WATER MAINS AND/OR WATER SERVICES WHENEVER POSSIBLE.
25. TREES SHALL BE PLACED SO AS TO AVOID BURIED UTILITIES.

- 26. ALL UTILITY MAIN LENGTHS SHOWN ARE APPROXIMATE. ALL MANHOLE TOP ELEVATIONS ARE APPROXIMATE.
27. ALL FIRE HYDRANTS SHALL BE INSTALLED WITH HOSE CONNECTIONS FACING THE BUILDING.
28. PRESSURE PIPE TESTING SPECIFICATIONS SHALL REFERENCE THE TOWNSHIP/COUNTY AND/OR FIRE DEPARTMENT.
29. CONTRACTOR IS RESPONSIBLE FOR ALL NECESSARY INSPECTIONS AND/OR CERTIFICATIONS REQUIRED BY CODES AND/OR UTILITY SERVICE COMPANIES.
30. CONTRACTOR SHALL COORDINATE WITH ALL UTILITY COMPANIES FOR INSTALLATION REQUIREMENTS AND SPECIFICATIONS.
31. CONNECTION INTO AN EXISTING TOWNSHIP/COUNTY OWNED SYSTEM SHALL BE VIA A WET TAP.
32. THE UTILITIES SERVICE COMPANY SHALL NOT OWN OR MAINTAIN WATER AND SEWER LINES OR FACILITIES ON-SITE.

GRADING NOTES:


- 1. ALL PAVING AND GRADING CONSTRUCTION MATERIALS AND METHODS SHALL MEET THE STANDARD SPECIFICATIONS AND REQUIREMENTS OF THE TOWNSHIP.
2. CONTRACTOR IS RESPONSIBLE FOR DEMOLITION OF EXISTING STRUCTURES INCLUDING REMOVAL OF ANY EXISTING UTILITIES SERVING THE STRUCTURE.
3. THE CONTRACTOR IS SPECIFICALLY CAUTIONED THAT THE LOCATION AND/OR ELEVATION OF EXISTING UTILITIES AS SHOWN ON THESE PLANS IS BASED ON RECORDS OF THE VARIOUS UTILITY COMPANIES.
4. ALL CUT OR FILL SLOPES SHALL BE 4:1 OR FLATTER UNLESS OTHERWISE NOTED.
5. PRECAST STRUCTURES ARE REQUIRED.
6. STORM PIPES TO BE CLEANED OUT TO REMOVE ALL SILT AND DEBRIS.
7. EXISTING CONTOUR INTERVALS SHOWN AT 1.0 FOOT.
8. PROPOSED CONTOUR INTERVALS SHOWN AT 1.0 FOOT.
9. IF ANY EXISTING STRUCTURES TO REMAIN ARE DAMAGED DURING CONSTRUCTION IT SHALL BE THE CONTRACTOR'S RESPONSIBILITY TO REPAIR AND/OR REPLACE THE EXISTING STRUCTURE AS NECESSARY TO RETURN IT TO EXISTING CONDITIONS OR BETTER.
10. ALL STORM PIPE ENTERING STRUCTURES SHALL BE GROUDED TO ASSURE CONNECTION AT STRUCTURE IS WATERTIGHT.
11. ALL STORM SEWER MANHOLES IN PAVED AREAS SHALL BE FLUSH WITH PAVEMENT, AND SHALL HAVE TRAFFIC BEARING RING & COVERS.
12. THE CONTRACTOR SHALL ADHERE TO ALL TERMS & CONDITIONS AS OUTLINED IN THE RIPDES OR APPLICABLE STATE GENERAL PERMIT FOR STORMWATER DISCHARGE ASSOCIATED WITH CONSTRUCTION ACTIVITIES.
13. CONTRACTOR SHALL ADJUST AND/OR CUT EXISTING PAVEMENT AS NECESSARY TO ASSURE A SMOOTH FIT AND CONTINUOUS GRADE.
14. CONTRACTOR SHALL ASSURE POSITIVE DRAINAGE AWAY FROM BUILDINGS FOR ALL NATURAL AND PAVED AREAS.
15. TOPOGRAPHIC INFORMATION IS TAKEN FROM A TOPOGRAPHIC SURVEY BY LAND SURVEYORS.
16. ALL UNSURFACED AREAS DISTURBED BY GRADING OPERATION SHALL RECEIVE 4 INCHES OF TOPSOIL.
17. CONSTRUCTION SHALL COMPLY WITH ALL APPLICABLE GOVERNING CODES AND BE CONSTRUCTED TO SAME.
18. ALL STORM STRUCTURES SHALL HAVE A SMOOTH UNIFORM POURED MORTAR INVERT FROM INVERT IN TO INVERT OUT, UNLESS OTHERWISE NOTED.
19. CONTRACTOR TO MAINTAIN 1.5% MAXIMUM CROSS-SLOPE ON ALL SIDEWALKS AND CROSSWALKS.
20. CONTRACTOR TO PROVIDE POSITIVE DRAINAGE AWAY FROM ALL STRUCTURES WITH 2% MINIMUM SLOPE IN PERVIOUS AREAS AND 1.5% MINIMUM SLOPE IN PAVED AREAS UNLESS OTHERWISE NOTED.
21. FOLLOWING DEMOLITION, CLEARING/GRUBBING OPERATIONS, DESIGN CUTS, AND ADDITIONAL CUTTING TO REMOVE UNSUITABLE CONDITIONS AND PRIOR TO FILL PLACEMENT AND NEW CONSTRUCTION, THE ENTIRE SITE SHOULD BE PROOF-COMPACTED WITH MULTIPLE PERPENDICULAR PASSES OF A LARGE (15-TONSTATIC WEIGHT) VIBRATORY ROLLER TO COMPACT LOOSE, NEAR SURFACE SOILS.
22. CONTRACTOR TO ADD WATERPROOFING AT ALL LOCATIONS WHERE THE EXTERIOR GRADE IS PROPOSED ABOVE THE FINISHED FLOOR ELEVATION.

STANDARD ABBREVIATIONS

Table with 2 columns: Abbreviation and Full Name. Includes entries like AC (ACRES), ADA (AMERICANS WITH DISABILITY ACT), ARCH (ARCHITECTURAL), BC (BOTTOM OF CURB), BF (BASEMENT FLOOR), BK (BLOCK), BL (BASELINE), BLD (BUILDING), BOL (BOLLARD), BM (BENCH MARK), BRL (BUILDING RESTRICTION LINE), CF (CUBIC FEET), CL (CENTERLINE), CMP (CORRUGATED METAL PIPE), CONC (CONCRETE), CPP (CORRUGATED PLASTIC PIPE), CY (CUBIC YARDS), DEC (DECORATIVE), DEP (DEPRESSED), DIP (DUCTILE IRON PIPE), DOM (DOMESTIC), ELEC (ELECTRIC), ELEV (ELEVATION), EP (EDGE OF PAVEMENT), ES (EDGE OF SHOULDER), EW (END OF WALL), EX (EXISTING), FES (FLARED END SECTION), FF (FINISH FLOOR ELEVATION), FH (FIRE HYDRANT), FG (FINISHED GRADE), G (GRADE), GF (GARAGE FLOOR), GH (GRADE HIGH SIDE OF WALL), GL (GRADE LOW SIDE OF WALL), GRT (GRATE), GV (GATE VALVE), HDPE (HIGH DENSITY POLYETHYLENE PIPE), HP (HIGH POINT), HOR (HORIZONTAL), HW (HEADWALL), INT (INTERSECTION), INV (INVERT), LF (LINEAR FOOT), LOC (LIMITS OF CLEARING), LOD (LIMITS OF DISTURBANCE), LOS (LINE OF SIGHT), LP (LOW POINT), LS (LANDSCAPE), MAX (MAXIMUM), MIN (MINIMUM), MH (MANHOLE), MJ (MECHANICAL JOINT), OC (ON CENTER), PC (POINT OF CURVATURE), PCCR (POINT OF COMPOUND CURVATURE, CURB RETURN), PI (POINT OF INTERSECTION), POG (POINT OF GRADE), POI (POINT OF INTEREST), PROP (PROPOSED), PT (POINT OF TANGENCY), PTCR (POINT OF TANGENCY, CURB RETURN), PVC (POLYVINYL CHLORIDE PIPE), PVI (POINT OF VERTICAL INTERSECTION), PVT (POINT OF VERTICAL TANGENCY), R (RADIUS), RCP (REINFORCED CONCRETE PIPE), RCPR (REINFORCED CONCRETE WITH RUBBER GASKET), RET-WALL (RETAINING WALL), RW (RIGHT OF WAY), S (SLOPE), SAN (SANITARY SEWER), SF (SQUARE FEET), STA (STATION), STM (STORM), TBR (TO BE REMOVED), TBRL (TO BE RELOCATED), TC (TOP OF CURB), TEL (TELEPHONE), TP (TREE PROTECTION), TW (TOP OF WALL), TYP (TYPICAL), UG (UNDERGROUND), UP (UTILITY POLE), WL (WATER LINE), WM (WATER METER), +/- (PLUS OR MINUS), ° (DEGREE), Ø (DIAMETER), # (NUMBER)



DOCUMENTS PREPARED BY CORESTATES, INC., INCLUDING THIS DOCUMENT ARE TO BE USED ONLY FOR THE SPECIFIC PROJECT AND SPECIFIC USE FOR WHICH THEY WERE INTENDED.

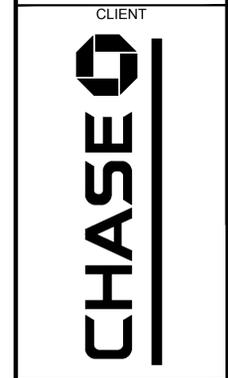


Know what's below. Call before you dig. The contractor is specifically cautioned that the location and/or elevation of existing utilities as shown on these plans is based on records of the various utility companies.

Table with 4 columns: REV, DATE, COMMENT, BY. Row 1: 1, 06/01/20, REVISED PER TOWNSHIP COMMENTS, KGF

DOCUMENT SITE PLAN APPROVAL FOR CHASE BANK. SITE LOCATION MAIN STREET & BAKER AVENUE 1134 MAIN STREET CONCORD, MA 01742

ENGINEER SEAL. ALAN D. ROSCOE, P.E. MA LICENSE #40163. SHEET TITLE GENERAL NOTES. JOB #: JPM-27599. DATE: 04/28/2020. SCALE: AS SHOWN. DRAWN BY: CC. CHECKED BY: TP. SHEET NO. CV-2

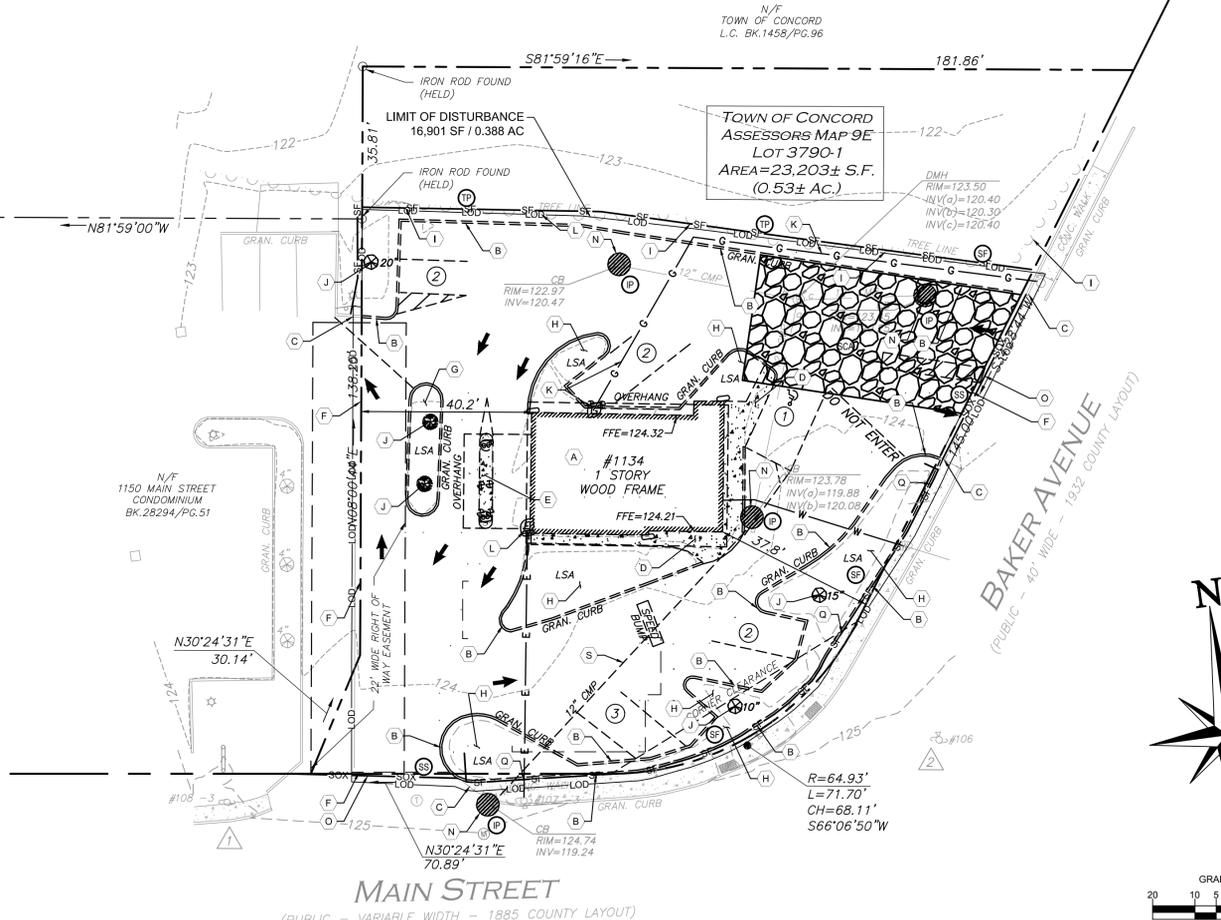

DEMOLITION NOTES:

1. THE CONTRACTOR SHALL COMPLY WITH ALL FEDERAL, STATE AND LOCAL LAWS AND CODES AND OBTAIN ALL REQUIRED PERMITS FOR ANY CONSTRUCTION ACTIVITY.
2. THE CONTRACTOR SHALL CONTACT 811 DIG SAFELY BEFORE PERFORMING ANY EXCAVATION WORK.
3. THE CONTRACTOR SHALL INSTALL ALL CONSTRUCTION FENCING AND EROSION AND SEDIMENT CONTROL DEVICES PRIOR TO THE START OF ANY DEMOLITION OR CONSTRUCTION ACTIVITY.
4. ALL STRUCTURES, UTILITIES, SITE IMPROVEMENTS AND TREES DESIGNATED ON THE DRAWINGS OR DIRECTED BY THE ENGINEER TO REMAIN SHALL BE PROTECTED FROM DAMAGE BY ALL CONSTRUCTION OPERATIONS. THIS SHALL BE ACCOMPLISHED BY ERECTING BARRIERS, GUARDS AND ENCLOSURES AS SHOWN ON THE DRAWINGS OR OTHER APPROVED MEANS. PROTECTION SHALL BE MAINTAINED UNTIL ALL WORK IN THE VICINITY OF THE WORK BEING PROTECTED HAS BEEN COMPLETED.
5. THE CONTRACTOR SHALL COMPLY WITH ALL DEMOLITION AND NEW CONSTRUCTION INSPECTIONS AS REQUIRED BY FEDERAL, STATE AND MUNICIPAL AUTHORITY HAVING JURISDICTION LAWS, REGULATIONS AND BUILDING CODES.
6. THE CONTRACTOR IS RESPONSIBLE FOR THE DEMOLITION, REMOVAL, AND DISPOSAL (IN A LOCATION APPROVED BY ALL AUTHORITIES HAVING JURISDICTION) ALL STRUCTURES, PADS, WALLS, FLUMES, FOUNDATIONS, PARKING, DRIVES, DRAINAGE, STRUCTURES, UTILITIES, ETC., SUCH THAT THE IMPROVEMENTS SHOWN ON THE REMAINING PLANS CAN BE CONSTRUCTED. UTILITIES ARE TO BE REMOVED TO THE RIGHT-OF-WAY, UNLESS OTHERWISE NOTED.
7. ALL FACILITIES TO BE REMOVED SHALL BE UNDERCUT TO SUITABLE MATERIAL AND BROUGHT TO GRADE WITH SUITABLE COMPACTED FILL MATERIAL PER THE CONTRACT DOCUMENTS.
8. CONTRACTOR IS TO REMOVE AND DISPOSE OF ALL DEBRIS, RUBBISH, VEGETATION FROM CLEARING AND GRUBBING, AND OTHER MATERIALS RESULTING FROM PREVIOUS AND CURRENT DEMOLITION OPERATIONS. DISPOSAL WILL BE IN ACCORDANCE WITH ALL LOCAL, STATE AND/OR FEDERAL REGULATIONS GOVERNING SUCH OPERATIONS. THE CONTRACTOR IS RESPONSIBLE FOR OBTAINING FOR ALL PERMITS REQUIRED FOR DEMOLITION AND DISPOSAL.
9. THE CONTRACTOR IS RESPONSIBLE FOR REMOVING ALL DEBRIS FROM THE SITE AND DISPOSING THE DEBRIS IN A LAWFUL MANNER. THE CONTRACTOR IS RESPONSIBLE FOR OBTAINING ALL PERMITS REQUIRED FOR DEMOLITION AND DISPOSAL.
10. THE CONTRACTOR SHALL COORDINATE WITH RESPECTIVE UTILITY COMPANIES PRIOR TO THE REMOVAL AND/OR RELOCATION OF UTILITIES. THE CONTRACTOR SHALL COORDINATE WITH THE UTILITY COMPANY CONCERNING PORTIONS OF WORK WHICH MAY BE PERFORMED BY THE UTILITY COMPANY'S FORCES AND ANY FEES WHICH ARE TO BE PAID TO THE UTILITY COMPANY FOR THEIR SERVICES. THE CONTRACTOR IS RESPONSIBLE FOR PAYING ALL FEES AND CHARGES.
11. THE LOCATIONS OF ALL EXISTING UTILITIES SHOWN ON THIS PLAN HAVE BEEN DETERMINED FROM THE BEST INFORMATION AVAILABLE AND ARE GIVEN FOR THE CONVENIENCE OF THE CONTRACTOR. THE ENGINEER ASSUMES NO RESPONSIBILITY FOR THEIR ACCURACY. PRIOR TO THE START OF ANY DEMOLITION ACTIVITY, THE CONTRACTOR SHALL NOTIFY THE UTILITY COMPANIES FOR ONSITE LOCATIONS OF EXISTING UTILITIES.
12. ALL EXISTING SEWERS, PIPING AND UTILITIES SHOWN ARE NOT TO BE INTERPRETED AS THE EXACT LOCATION, OR AS THE ONLY OBSTACLES THAT MAY OCCUR ON THE SITE. VERIFY EXISTING CONDITIONS AND PROCEED WITH CAUTION AROUND ANY ANTICIPATED FEATURES. GIVE NOTICE TO ALL UTILITY COMPANIES REGARDING DESTRUCTION AND REMOVAL OF ALL SERVICE LINES AND CAP ALL LINES BEFORE PROCEEDING WITH THE WORK. UTILITIES DETERMINED TO BE ABANDONED AND LEFT IN PLACE SHALL BE GROUTED IF UNDER BUILDING.
13. ELECTRICAL, TELEPHONE, CABLE, WATER, FIBER OPTIC CABLE AND/OR GAS LINES NEEDING TO BE REMOVED OR RELOCATED SHALL BE COORDINATED WITH THE AFFECTED UTILITY COMPANY AND REMOVED TO THE PROPERTY LINE. ADEQUATE TIME SHALL BE PROVIDED FOR RELOCATION AND CLOSE COORDINATION WITH THE UTILITY COMPANY IS NECESSARY TO PROVIDE A SMOOTH TRANSITION IN UTILITY SERVICE. CONTRACTOR SHALL PAY CLOSE ATTENTION TO EXISTING UTILITIES WITHIN ANY ROAD RIGHT OF WAY DURING CONSTRUCTION.
14. CONTRACTOR TO REPLACE ALL DEAD AND/OR DAMAGED SHRUBS IN KIND.
15. ALL BELOW GRADE CONSTRUCTION INCLUDING BELOW- GRADE WALLS, SLABS AND TANKS ARE TO BE REMOVED.
16. PLAN DEPICTS ALL KNOWN STRUCTURES AND UTILITIES ABOVE AND/OR UNDERGROUND. ADDITIONAL UNDERGROUND UTILITIES AND/OR STRUCTURES MAY EXIST. CONTRACTOR SHALL NOTIFY ENGINEER OF RECORD IF ADDITIONAL UTILITIES OR STRUCTURES ARE ENCOUNTERED AND COORDINATE WITH THE MUNICIPALITY OR UTILITY COMPANY FOR PROPER REMOVAL OR RELOCATION.
17. THE TOTAL LIMITS OF DISTURBANCE FOR THIS PROJECT IS XX,XXX SF (X.XX AC).

GENERAL NOTES:

1. THIS PROJECT REFERENCES A SURVEY PREPARED BY: ALLEN & MAJOR ASSOCIATES, INC. 100 COMMERCE WAY WOBURN, MA 01801
- DATE: JANUARY 30, 2020
EXISTING CONDITIONS
LOT 3790-1
1134 MAIN STREET
TOWN OF CONCORD
COUNTY OF MIDDLESEX
STATE OF MASSACHUSETTS

KEYED NOTES:

- A. EXISTING BUILDING AND CANOPIES TO BE REMOVED.
- B. EXISTING CURB TO BE REMOVED.
- C. LIMIT OF CURB REMOVAL. CONTRACTOR TO PROTECT IN PLACE EXISTING CURB AND REPAIR ANY DAMAGE DONE DURING CONSTRUCTION.
- D. EXISTING CONCRETE WALK TO BE REMOVED.
- E. EXISTING ATM, BOLLARDS, AND ATM ISLAND TO BE REMOVED.
- F. PROPOSED SAWCUT LINE.
- G. EXISTING LANDSCAPED ISLAND TO BE REMOVED.
- H. EXISTING LANDSCAPE TO BE REMOVED.
- I. EXISTING TREE LINE TO REMAIN.
- J. EXISTING TREE TO BE REMOVED. REFER TO LANDSCAPE PLANS.
- K. EXISTING GAS LINE AND METERS TO BE REMOVED. CONTRACTOR TO COORDINATE WITH UTILITY COMPANY PRIOR TO CONSTRUCTION.
- L. EXISTING ELECTRICAL LINES AND METERS TO BE REMOVED. CONTRACTOR TO COORDINATE WITH UTILITY COMPANY PRIOR TO CONSTRUCTION.
- M. EXISTING LIGHT POLES AND ELECTRICAL LINES TO BE REMOVED. CONTRACTOR TO COORDINATE WITH UTILITY COMPANY PRIOR TO CONSTRUCTION.
- N. EXISTING STORM STRUCTURE TO REMAIN CONTRACTOR TO PROTECT IN PLACE. CONTRACTOR PATCH AND REPAIR AS NECESSARY DURING PIPE REMOVAL AND PROPOSED WORK.
- O. PROPOSED EROSION CONTROL SILT SOXX. SEE CONSTRUCTION DETAIL SHEETS.
- P. EXISTING WATER LINE TO BE REMOVED AND CAPPED. CONTRACTOR TO COORDINATE WATER LINE INSTALLATION WITH UTILITY COMPANY.
- Q. PROPOSED EROSION CONTROL SILT FENCE. SEE CONSTRUCTION DETAIL SHEETS.
- R. PROPOSED TREE PROTECTION. SEE CONSTRUCTION DETAIL SHEETS.
- S. EXISTING STORM PIPE TO BE REMOVED.

CORE STATES INC.

1270 Haverhill Road
Dorset, MA 01920
314.377.5060
www.corestates.com

DOCUMENTS PREPARED BY CORE STATES, INC. INCLUDING THIS DOCUMENT ARE TO BE USED ONLY FOR THE SPECIFIC PROJECT AND SPECIFIC USE FOR WHICH THEY WERE INTENDED. ANY EXTENSION OF USE TO ANY OTHER PROJECTS, BY OWNER OR BY ANY OTHER PARTY, WITHOUT THE EXPRESSED WRITTEN CONSENT OF CORE STATES, INC. IS DONE UNLAWFULLY AND AT THE USER'S OWN RISK. IF USED IN A WAY OTHER THAN THAT SPECIFICALLY INTENDED, USER WILL HOLD CORE STATES, INC. HARMLESS FROM ALL CLAIMS AND LOSSES.

CLIENT

CHASE

811

Know what's below. Call before you dig.

REVISIONS

REV	DATE	COMMENT	BY
1	06/01/20	REVISED PER TOWNSHIP COMMENTS	KGF

DOCUMENT SITE PLAN APPROVAL FOR CHASE BANK

SITE LOCATION MAIN STREET & BAKER AVENUE 1134 MAIN STREET CONCORD, MA 01742

ENGINEER SEAL

ALAN D. ROSCOE, P.E.
MA LICENSE #40163

SHEET TITLE DEMOLITION PLAN

JOB #:	JPM-27599
DATE:	04/28/2020
SCALE:	AS NOTED
DRAWN BY:	CC
CHECKED BY:	TP

SHEET NO.
C-1

ALERT TO CONTRACTOR:


PRIOR TO THE CONSTRUCTION OF OR CONNECTION TO ANY STORM DRAIN, SANITARY SEWER, WATER MAIN OR ANY OF THE DRY UTILITIES, THE CONTRACTOR SHALL EXCAVATE, VERIFY AND CALCULATE ALL POINTS OF CONNECTION AND ALL UTILITY CROSSINGS AND INFORM ENGINEER AND THE OWNER OF ANY CONFLICT OR REQUIRED DEVIATIONS FROM THE PLAN. NOTIFICATION SHALL BE MADE A MINIMUM OF 48 HOURS PRIOR TO CONSTRUCTION. ENGINEER AND OWNER SHALL BE HELD HARMLESS IN THE EVENT THAT THE CONTRACTOR FAILS TO MAKE SUCH NOTIFICATION.

E & S LEGEND

—SF—	Ⓢ	SILT FENCE (REFER TO CONSTRUCTION DETAIL SHEET.)
—SOX—	Ⓢ	SILT SOXX (REFER TO CONSTRUCTION DETAIL SHEET.)
Ⓢ	Ⓢ	INLET PROTECTION (REFER TO CONSTRUCTION DETAIL SHEET.)
Ⓢ	Ⓢ	TREE PROTECTION (REFER TO CONSTRUCTION DETAIL SHEET.)
Ⓢ	Ⓢ	STABILIZED CONSTRUCTION ENTRANCE (REFER TO CONSTRUCTION DETAIL SHEET)


EXISTING LEGEND

---	PROPERTY BOUNDARY LINE
---	CENTER LINE OF EXISTING ROADWAY
---	ADJOINING PROPERTY LINE
---	EXISTING CURB
---	EXISTING EDGE OF PAVEMENT
---	EXISTING FENCE
---	EXISTING BLOCK NUMBER
---	EXISTING LOT NUMBER
---	EXISTING 5' INTERVAL CONTOUR LINE
---	EXISTING 1' INTERVAL CONTOUR LINE
Ⓢ	EXISTING TREE
---	EXISTING GAS MAIN
---	EXISTING UTILITY POLE
---	EXISTING STORM STRUCTURES
---	EXISTING SANITARY STRUCTURES
---	EXISTING WATER MAIN
---	EXISTING FIRE HYDRANT
---	EXISTING WATER VALVE
---	EXISTING UNDERGROUND ELECTRIC
---	EXISTING TELEPHONE
---	EXISTING OVERHEAD WIRES
---	EXISTING SANITARY
---	EXISTING STORM
---	DEMO CURB
---	DEMO GRAVEL ROAD
---	DEMO ASPHALT
---	DEMO PROPERTY LINE
Ⓢ	DEMO TREE
---	DEMO UTILITY POLE
---	PROPOSED SAWCUT LINE
---	LIMITS OF DISTURBANCE

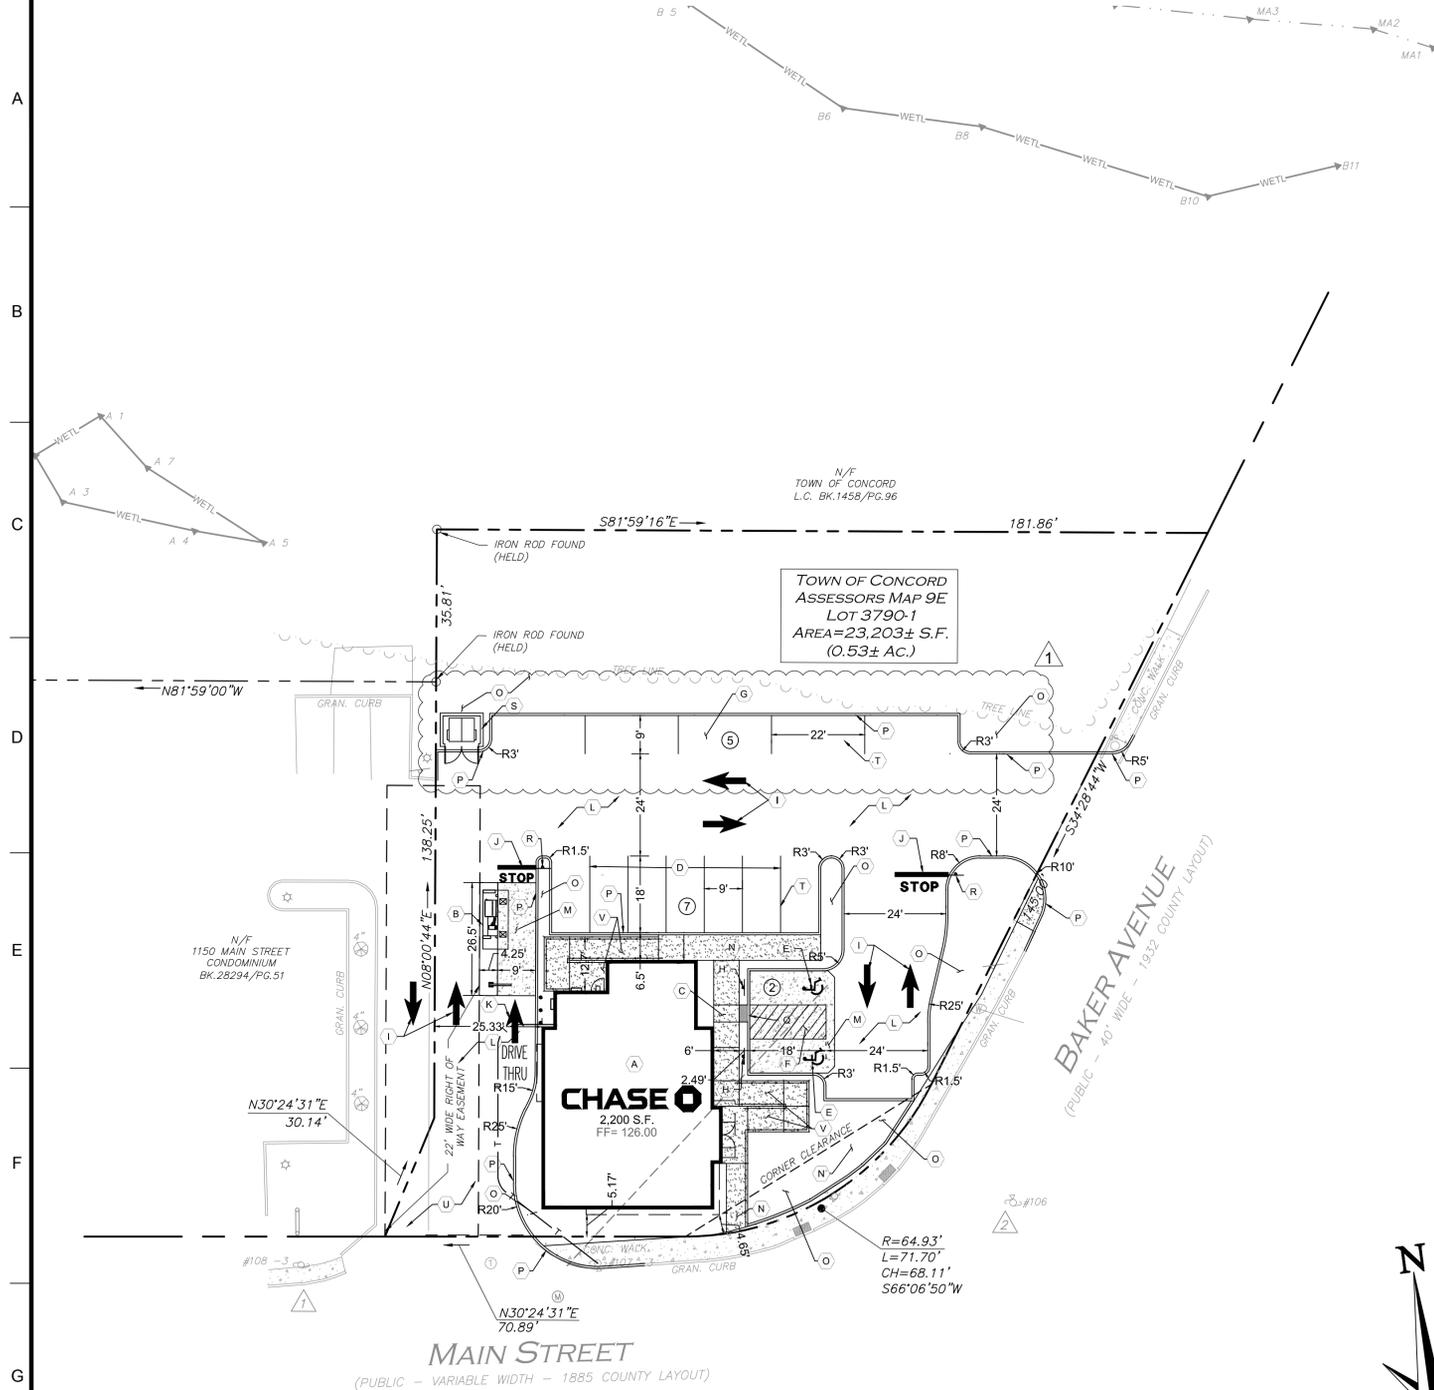

TOWN OF CONCORD
ASSESSORS MAP 9E
LOT 3790-1
AREA=23,203± S.F.
(0.53± AC.)

CHASE
2,200 S.F.
FF= 126.00

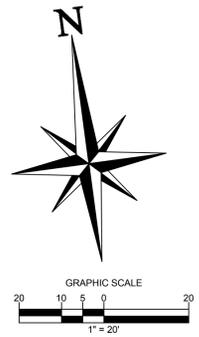

ZONING DATA (WEST CONCORD BUSINESS DISTRICT- WCB) - LOT 3790-1				
ITEM	REQUIRED	EXISTING	PROPOSED	COMMENT
MIN. LOT AREA	-	23,203 SF	23,203 SF	COMPLIANT
MIN. LOT FRONTAGE	-	288 FT	288 FT	COMPLIANT
FRONTAGE EXCEPTION	-	N/A	N/A	COMPLIANT
MIN. LOT WIDTH	-	77.08 FT	77.08 FT	COMPLIANT
CORNER CLEARANCE	10 FEET*	N/A	-	COMPLIANT*
MIN. BUILDING FRONT SETBACK	0 FEET	37.8 FT	5.17 FT	COMPLIANT
MIN. REAR SETBACK	0 FEET	40.2 FT	25.33 FT	COMPLIANT
MAX. BUILDING HEIGHT	35 FEET**	N/A	26.3 FT	COMPLIANT
MAXIMUM LOT COVERAGE	-	57.67%	57.38%	COMPLIANT
MAXIMUM FLOOR TO AREA RATIO	-	5.57%	9.48%	COMPLIANT

PARKING CALCULATIONS:

EXISTING:
LOT 3790-1 = 10 SPACES (TOTAL) (9 REG + 1 HC)

PROPOSED:
LOT 3790-1 = 14 SPACES (TOTAL) (11 REG + 2 HC)
1 SPACE PROVIDED AT DRIVE-UP ATM
TOTAL = 15 SPACES PROVIDED

REQUIRED:
MINIMUM ALLOWED:
FOR BANK USE = 1 SPACE FOR 250 GFA + 2 SPACES PER ATM
= 2,200 SF X 1 SPACE PER 250 SF = 9 SPACES
= 3 INTERIOR ATMS X 2 SPACES PER ATM = 6 SPACES
= 9 SPACES + 6 SPACES = 15 SPACES MINIMUM REQUIRED

* = BETWEEN THE SIDELINES OF THE INTERSECTING STREETS AND A STRAIGHT LINE JOINING POINTS ON SUCH SIDELINES TEN (10) FEET DISTANT FROM THEIR POINT OF INTERSECTION OR, IN THE CASE OF A ROUNDED CORNER, A STRAIGHT LINE JOINING THE POINTS OF INTERSECTION OF THEIR TANGENTS, NO BUILDING OR STRUCTURE MAY BE ERRECTED AND NO VEGETATION MAY BE MAINTAINED THREE (3) FEET ABOVE THE PLANE THROUGH THEIR CURB GRADES.

** = MAXIMUM HEIGHT IS 35 FEET AND MINIMUM HEIGHT SIDE AND REAR IS 15'. MINIMUM HEIGHT FOR FRONT FACADE IS 18'.

GENERAL NOTES:

- THIS PROJECT REFERENCES A SURVEY PREPARED BY:
ALLEN & MAJOR ASSOCIATES, INC.
100 COMMERCE WAY
WOBURN, MA 01801
- DATE: JANUARY 30, 2020
EXISTING CONDITIONS
LOT 3790-1
1134 MAIN STREET
TOWN OF CONCORD
COUNTY OF MIDDLESEX
STATE OF MASSACHUSETTS

PROPERTY INFORMATION:

THIS DRAWING REFERENCES: 1134 MAIN STREET, TOWN OF CONCORD
EXISTING CONDITIONS
PREPARED BY: ALLEN & MAJOR ASSOCIATES, INC.
100 COMMERCE WAY
WOBURN, MA 01801
CONTACT: CHARLES OSBORNE, PLS
TEL: (732) 422-6700

PROPERTY OWNER: NIKOEL LLC.
78 RHODE ISLAND AVENUE #3
NEWPORT, RI 02840

APPLICANT: J.P. MORGAN CHASE BANK
1450 BRICKELL AVENUE 3RD FLOOR
MIAMI, FL 33131
CONTACT: CHRIS FOIT
TEL: (786) 473-1769

SITE ADDRESS: 1134 MAIN STREET
CONCORD, MA 01742
COUNTY OF MIDDLESEX

ZONING DATA: ZONED: WEST CONCORD BUSINESS DISTRICT (WCB)
EXISTING USE: BANK (PERMITTED)
PROPOSED USE: BANK (PERMITTED)
: DRIVE THRU
(SPECIAL USE APPROVAL, APPROVED BY TOWNSHIP)

NOTE: THE PROPOSED FORMULA BUSINESS USE (CHASE WITH DRIVE-UP ATM) FOR THIS PARCEL LOT MATCHES THE EXISTING FORMULA BUSINESS USE (EXISTING CITIZENS BANK WITH DRIVE-UP ATM) IN THE WEST CONCORD BUSINESS DISTRICT WHERE FORMULA BUSINESSES ARE LIMITED.


GENERAL DEVELOPMENT NOTES:

- FINISH WALK AND CURB ELEVATIONS SHALL BE 6" ABOVE FINISH PAVEMENT UNLESS OTHERWISE NOTED ON THESE PLANS.
- ALL FEATURES SHOWN ARE EXISTING UNLESS OTHERWISE INDICATED.
- ALL DIMENSIONS FOR PROPERTY LINES ARE PERPENDICULAR UNLESS OTHERWISE NOTED.
- THE CONTRACTOR WILL BE RESPONSIBLE FOR MAINTAINING THE SITE UNTIL WORK IS ACCEPTED BY THE OWNER.
- ANY DAMAGE TO THE EXISTING CURB AS A RESULT OF THIS DEVELOPMENT MUST BE REPLACED AS NECESSARY.
- IT IS THE RESPONSIBILITY OF THE CONTRACTOR TO REMOVE ANY DEBRIS AND FLUSH OUT ALL EXISTING AND NEW STORM DRAINAGE FACILITIES WITHIN THE PROJECT LIMITS AT THE COMPLETION OF THE CONSTRUCTION.
- ALL NEW BUILDING SIGNAGE WILL COMPLY WITH ZONING REGULATIONS.
- PROVIDE ADEQUATE OFF-STREET PARKING FOR CONSTRUCTION EMPLOYEES. PARKING ON NON-SURFACED AREAS SHALL BE PROHIBITED IN ORDER TO ELIMINATE THE CONDITION WHEREBY MUD FROM CONSTRUCTION AND EMPLOYEE VEHICLES IS TRACKED ONTO THE PAVEMENT CAUSING HAZARDOUS ROADWAY AND DRIVEWAY CONDITIONS.
- ALL QUANTITIES SHOWN ON PLANS ARE APPROXIMATE AND FOR REFERENCE ONLY.
- CONTRACTOR TO VERIFY ALL MINIMUMS CALLED OUT ON THE CIVIL PLANS AND SHALL NOTIFY ENGINEER AND ACM IF MINIMUMS CANNOT BE MET.
- REFER TO SHEET CV2 FOR GENERAL NOTES.


KEYED NOTES:

- A. PROPOSED CHASE BANK
- B. PROPOSED DRIVE-UP ATM.
- C. PROPOSED A.D.A. COMPLIANT RAMP. SEE DETAIL SHEET.
- D. PROPOSED 9' X 18' PARKING SPACE.
- E. PROPOSED 8' X 18' ACCESSIBLE PARKING SPACE.
- F. PROPOSED 8' X 18' ACCESSIBLE PARKING AISLE.
- G. PROPOSED 9' X 22' PARALLEL PARKING SPACE.
- H. PROPOSED ACCESSIBLE PARKING SIGNAGE. SEE DETAIL SHEET.
- I. PROPOSED REFLECTIVE DIRECTIONAL STRIPING. SEE DETAIL SHEET.
- J. PROPOSED STOP BAR. SEE DETAIL SHEET.
- K. PROPOSED DRIVE-THRU ARROW.
- L. PROPOSED STANDARD DUTY PAVEMENT. SEE DETAIL SHEET.
- M. PROPOSED CONCRETE PAD. SEE DETAIL SHEET.
- N. PROPOSED CONCRETE SIDEWALK. SEE DETAIL SHEET.
- O. PROPOSED GRASSED/LANDSCAPED AREA.
- P. PROPOSED CONCRETE CURB. SEE DETAIL SHEET.
- Q. PROPOSED FLUSH CURB. SEE DETAIL SHEET.
- R. PROPOSED STOP SIGN. SEE DETAIL SHEET.
- S. PROPOSED DUMPSTER ENCLOSURE.
- T. PROPOSED PARKING SPACE STRIPING. SEE DETAIL SHEET.
- U. EXISTING 22-FT WIDE RIGHT-OF-WAY EASEMENT.
- V. PROPOSED RAISE RAMP WITH HANDRAILS. REFER TO TOWN OF CONCORD WHEELCHAIR RAMP DETAIL.

SITE LEGEND:

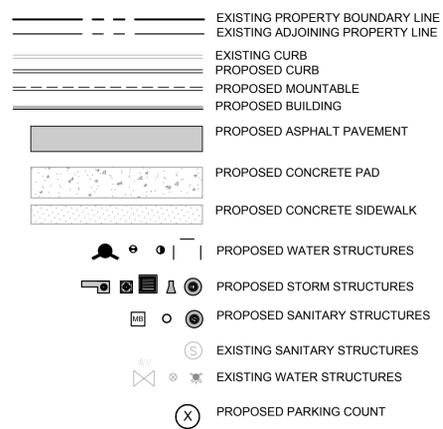

ALERT TO CONTRACTOR:
PRIOR TO THE CONSTRUCTION OF OR CONNECTION TO ANY STORM DRAIN, SANITARY SEWER, WATER MAIN OR ANY OF THE DRY UTILITIES, THE CONTRACTOR SHALL EXCAVATE, VERIFY AND CALCULATE ALL POINTS OF CONNECTION AND ALL UTILITY CROSSINGS AND INFORM ENGINEER AND THE OWNER OF ANY CONFLICT OR REQUIRED DEVIATIONS FROM THE PLAN. NOTIFICATION SHALL BE MADE A MINIMUM OF 48 HOURS PRIOR TO CONSTRUCTION. ENGINEER AND OWNER SHALL BE HELD HARMLESS IN THE EVENT THAT THE CONTRACTOR FAILS TO MAKE SUCH NOTIFICATION.

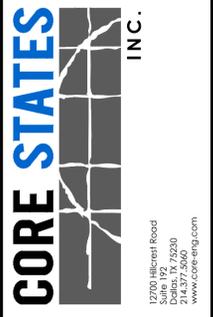

DOCUMENTS PREPARED BY CORE STATES, INC. INCLUDING THIS DOCUMENT ARE TO BE USED ONLY FOR THE SPECIFIC PROJECT AND SPECIFIC USE FOR WHICH THEY WERE INTENDED. ANY EXTENSION OF USE TO ANY OTHER PROJECTS, BY OWNER OR BY ANY OTHER PARTY, WITHOUT THE EXPRESSED WRITTEN CONSENT OF CORE STATES, INC. IS DONE UNLAWFULLY AND AT THE USER'S OWN RISK. IT IS HEREBY AGREED THAT CORE STATES, INC. SHALL BE HELD HARMLESS FROM ALL CLAIMS AND LOSSES.



REVISIONS			
REV	DATE	COMMENT	BY
1	06/01/20	REVISED PER TOWNSHIP COMMENTS	KGF

DOCUMENT SITE PLAN APPROVAL FOR CHASE BANK

SITE LOCATION
MAIN STREET & BAKER AVENUE
1134 MAIN STREET
CONCORD, MA 01742


ENGINEER SEAL
ALAN D. ROSCOE, P.E.
MA LICENSE #40163
SHEET TITLE

SITE PLAN
JOB #: JPM-27599
DATE: 04/28/2020
SCALE: AS SHOWN
DRAWN BY: CC
CHECKED BY: TP

SHEET NO.
C-2

GENERAL NOTES:

- THIS PROJECT REFERENCES A SURVEY PREPARED BY:
ALLEN & MAJOR ASSOCIATES, INC.
100 COMMERCE WAY
WOBURN, MA 01801
- DATE: JANUARY 30, 2020
EXISTING CONDITIONS
LOT 3790-1
1134 MAIN STREET
TOWN OF CONCORD
COUNTY OF MIDDLESEX
STATE OF MASSACHUSETTS

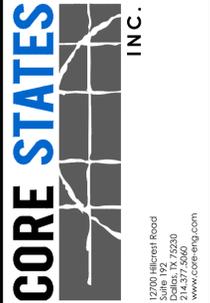

DOCUMENTS PREPARED BY CORE STATES, INC. INCLUDING THIS DOCUMENT ARE TO BE USED ONLY FOR THE SPECIFIC PROJECT AND SPECIFIC USE FOR WHICH THEY WERE INTENDED. ANY EXTENSION OF USE TO ANY OTHER PROJECTS, BY OWNER OR BY ANY OTHER PARTY, WITHOUT THE EXPRESSED WRITTEN CONSENT OF CORE STATES, INC. IS DONE UNLAWFULLY AND AT THE USER'S OWN RISK. IT IS USED IN A WAY OTHER THAN THAT SPECIFICALLY INTENDED. USER WILL HOLD CORE STATES, INC. HARMLESS FROM ALL CLAIMS AND LOSSES.

CLIENT



Know what's below. Call before you dig.

The CONTRACTOR is specifically cautioned that the location and/or location of existing utilities as shown on these plans is based on information furnished to the CONTRACTOR by the utility companies. CORE STATES, INC. DOES NOT GUARANTEE THE LOCATION OR DEPTH OF ANY UTILITIES SHOWN ON THESE PLANS. THE CONTRACTOR SHALL VERIFY THE LOCATION AND DEPTH OF ALL UTILITIES PRIOR TO CONSTRUCTION.

REVISIONS

REV	DATE	COMMENT	BY
1	06/01/20	REVISED PER TOWNSHIP COMMENTS	KGF

DOCUMENT SITE PLAN APPROVAL FOR CHASE BANK

SITE LOCATION
MAIN STREET & BAKER AVENUE
1134 MAIN STREET
CONCORD, MA 01742


ENGINEER SEAL

ALAN D. ROSCOE, P.E.
MA LICENSE #40163
SHEET TITLE
GRADING PLAN

JOB #:	JPM-27599
DATE:	04/28/2020
SCALE:	AS SHOWN
DRAWN BY:	CC
CHECKED BY:	TP


SHEET NO.
C-3

TOWN OF CONCORD
ASSESSORS MAP 9E
LOT 3790-1
AREA=23,203± S.F.
(0.53± AC.)

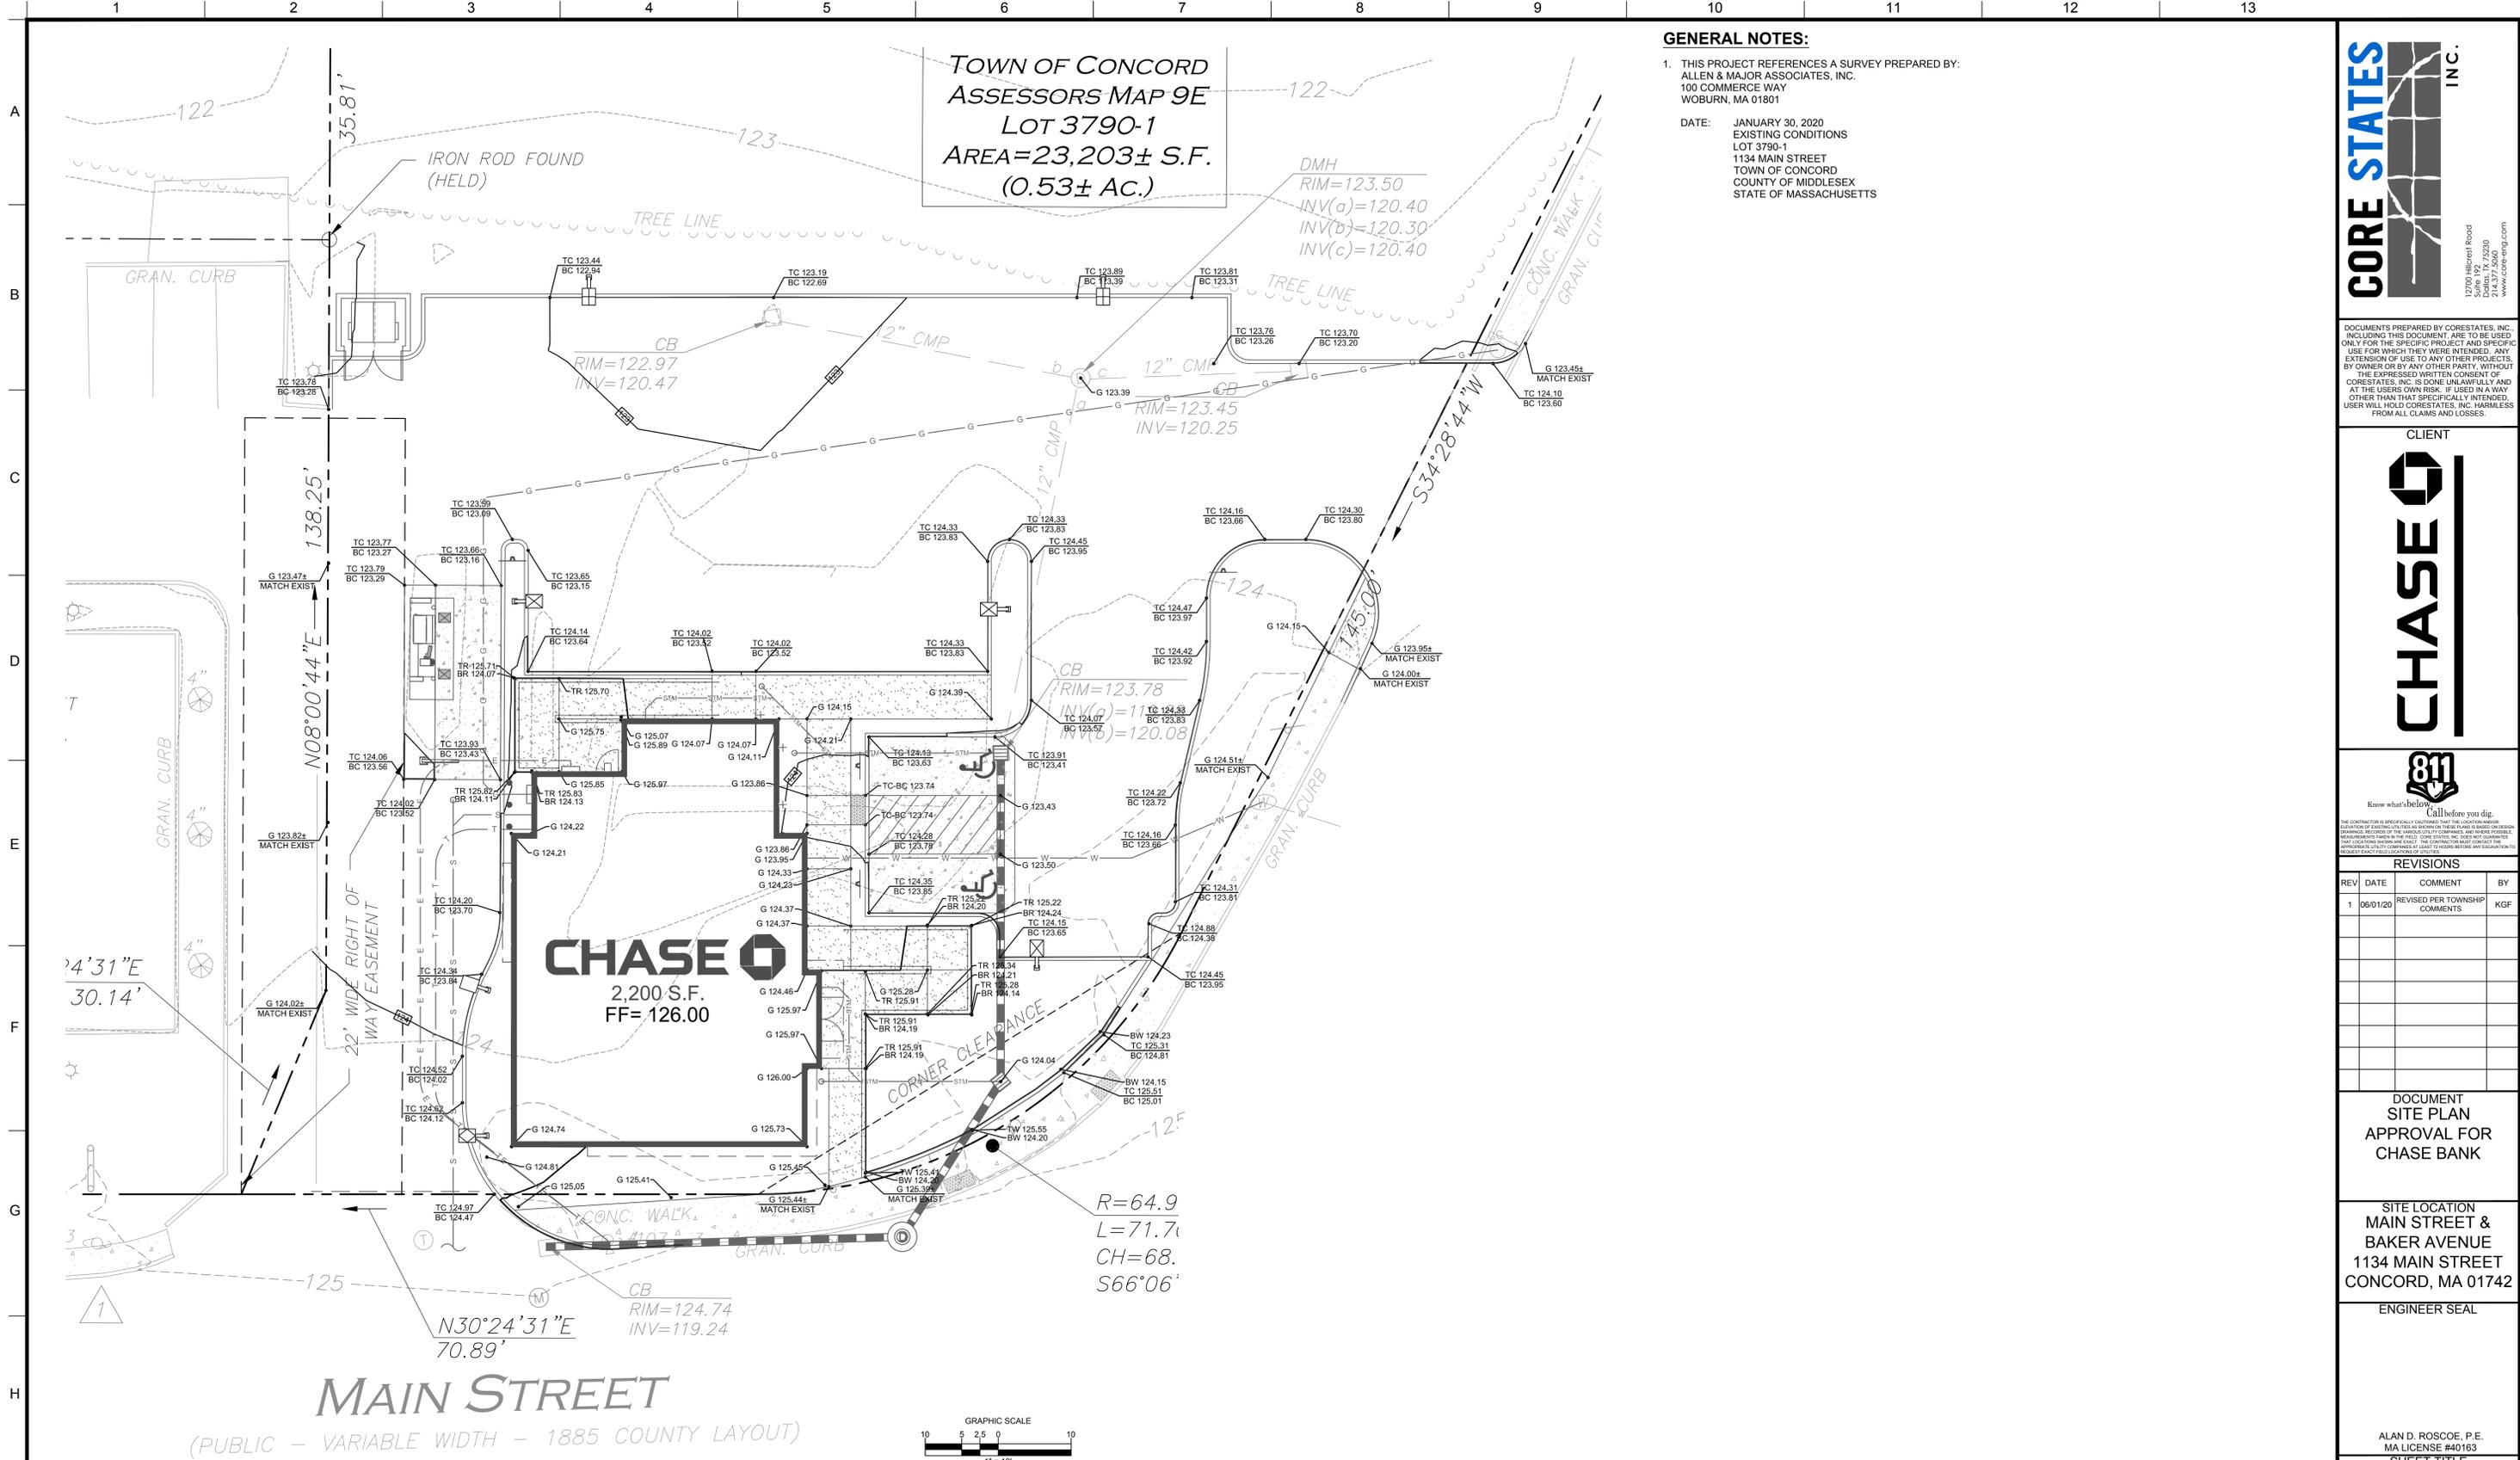

MAIN STREET

 (PUBLIC - VARIABLE WIDTH - 1885 COUNTY LAYOUT)



GRADING LEGEND

- EXISTING PROPERTY BOUNDARY LINE
- EXISTING ADJOINING PROPERTY LINE
- EXISTING ROAD CENTERLINE
- PROPOSED ROAD CENTERLINE
- PROPOSED DITCH CENTERLINE
- 165' EXISTING 5' INTERVAL CONTOUR LINE
- 166' EXISTING 1' INTERVAL CONTOUR LINE
- 165' PROPOSED 5' INTERVAL CONTOUR LINE
- 168' PROPOSED 1' INTERVAL CONTOUR LINE
- PROPOSED SPOT SHOTS

ALERT TO CONTRACTOR:
PRIOR TO THE CONSTRUCTION OF OR CONNECTION TO ANY STORM DRAIN, SANITARY SEWER, WATER MAIN OR ANY OF THE DRY UTILITIES, THE CONTRACTOR SHALL EXCAVATE, VERIFY AND CALCULATE ALL POINTS OF CONNECTION AND ALL UTILITY CROSSINGS AND INFORM ENGINEER AND THE OWNER OF ANY CONFLICT OR REQUIRED DEVIATIONS FROM THE PLAN. NOTIFICATION SHALL BE MADE A MINIMUM OF 48 HOURS PRIOR TO CONSTRUCTION. ENGINEER AND OWNER SHALL BE HELD HARMLESS IN THE EVENT THAT THE CONTRACTOR FAILS TO MAKE SUCH NOTIFICATION.

GENERAL NOTES:
 1. THIS PROJECT REFERENCES A SURVEY PREPARED BY:
 ALLEN & MAJOR ASSOCIATES, INC.
 100 COMMERCE WAY
 WOBURN, MA 01801
 DATE: JANUARY 30, 2020
 EXISTING CONDITIONS
 LOT 3790-1
 1134 MAIN STREET
 TOWN OF CONCORD
 COUNTY OF MIDDLESEX
 STATE OF MASSACHUSETTS

CORE STATES
 INC.
 1270 Haverhill Road
 Concord, MA 01730
 314.377.5660
 www.core-eng.com

DOCUMENTS PREPARED BY CORE STATES, INC., INCLUDING THIS DOCUMENT ARE TO BE USED ONLY FOR THE SPECIFIC PROJECT AND SPECIFIC USE FOR WHICH THEY WERE INTENDED. ANY EXTENSION OF USE TO ANY OTHER PROJECTS, BY OWNER OR BY ANY OTHER PARTY, WITHOUT THE EXPRESSED WRITTEN CONSENT OF CORE STATES, INC. IS DONE UNLAWFULLY AND AT THE USER'S OWN RISK. IT IS USED IN A WAY OTHER THAN THAT SPECIFICALLY INTENDED. USER WILL HOLD CORE STATES, INC. HARMLESS FROM ALL CLAIMS AND LOSSES.

CLIENT



 Know what's below. Call before you dig.
THE CONTRACTOR IS SPECIFICALLY CAUTIONED THAT THE LOCATION AND/OR DEPTH OF EXISTING UTILITIES SHOWN ON THESE DRAWINGS OR ON ANY RECORD DRAWINGS TAKEN IN THE FIELD, CORE STATES, INC. DOES NOT GUARANTEE. THE CONTRACTOR SHALL VERIFY THE LOCATION AND DEPTH OF ALL UTILITIES PRIOR TO ANY EXCAVATION OR DRILLING OPERATIONS. THE CONTRACTOR SHALL BE RESPONSIBLE FOR ANY DAMAGE TO UTILITIES OR OTHER PROPERTY CAUSED BY ANY EXCAVATION OR DRILLING OPERATIONS.

REV	DATE	COMMENT	BY
1	06/01/20	REVISED PER TOWNSHIP COMMENTS	KGF

DOCUMENT
 SITE PLAN
 APPROVAL FOR
 CHASE BANK



SITE LOCATION
 MAIN STREET &
 BAKER AVENUE
 1134 MAIN STREET
 CONCORD, MA 01742

ENGINEER SEAL
 ALAN D. ROSCOE, P.E.
 MA LICENSE #40163

SHEET TITLE
 POST-DEVELOPMENT
 DRAINAGE PLAN

JOB #: JPM-27599
 DATE: 04/28/2020
 SCALE: AS SHOWN
 DRAWN BY: CC
 CHECKED BY: TP


SHEET NO.
C-5

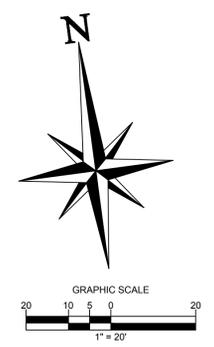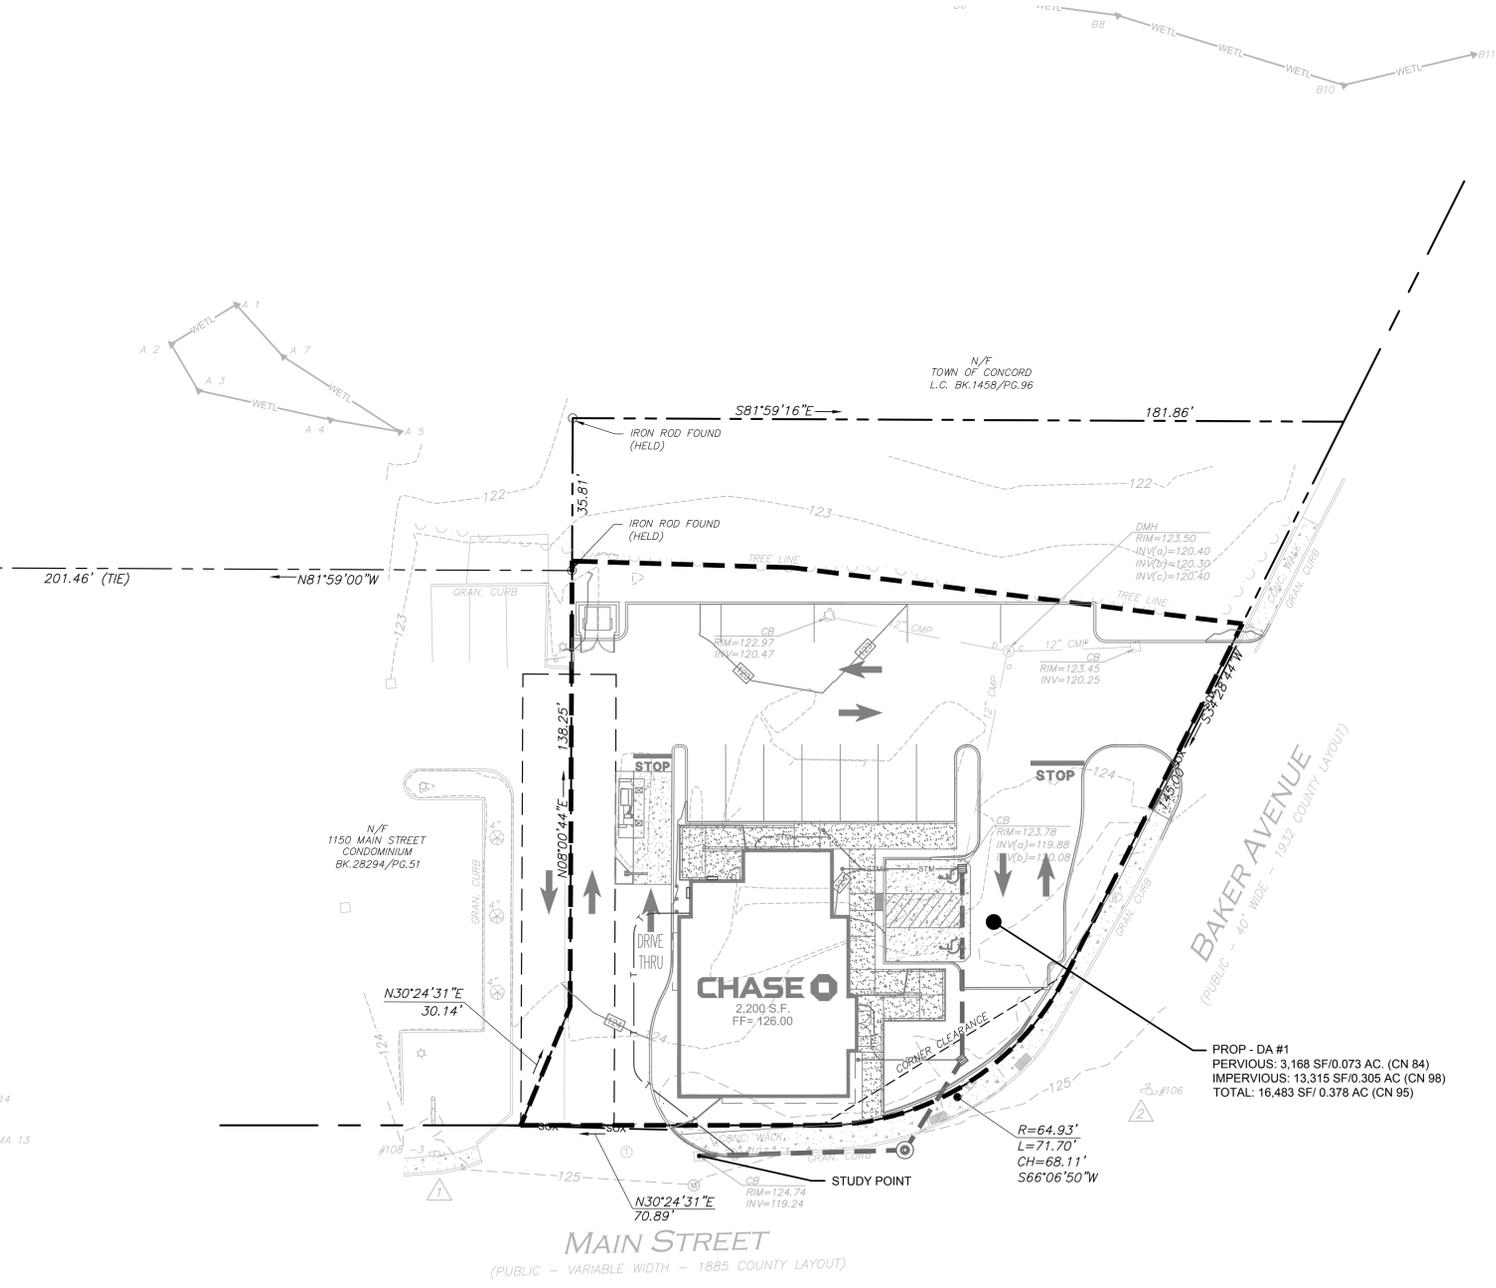

GRADING LEGEND

---	EXISTING PROPERTY BOUNDARY LINE
- - -	EXISTING ADJOINING PROPERTY LINE
---	EXISTING ROAD CENTERLINE
---	PROPOSED ROAD CENTERLINE
---	PROPOSED DITCH CENTERLINE
---	EXISTING 5' INTERVAL CONTOUR LINE
---	EXISTING 1' INTERVAL CONTOUR LINE
---	PROPOSED 5' INTERVAL CONTOUR LINE
---	PROPOSED 1' INTERVAL CONTOUR LINE
⊕ XX.XX	PROPOSED SPOT SHOTS

ALERT TO CONTRACTOR:
 PRIOR TO THE CONSTRUCTION OF OR CONNECTION TO ANY STORM DRAIN, SANITARY SEWER, WATER MAIN OR ANY OF THE DRY UTILITIES, THE CONTRACTOR SHALL EXCAVATE, VERIFY AND CALCULATE ALL POINTS OF CONNECTION AND ALL UTILITY CROSSINGS AND INFORM ENGINEER AND THE OWNER OF ANY CONFLICT OR REQUIRED DEVIATIONS FROM THE PLAN. NOTIFICATION SHALL BE MADE A MINIMUM OF 48 HOURS PRIOR TO CONSTRUCTION. ENGINEER AND OWNER SHALL BE HELD HARMLESS IN THE EVENT THAT THE CONTRACTOR FAILS TO MAKE SUCH NOTIFICATION.

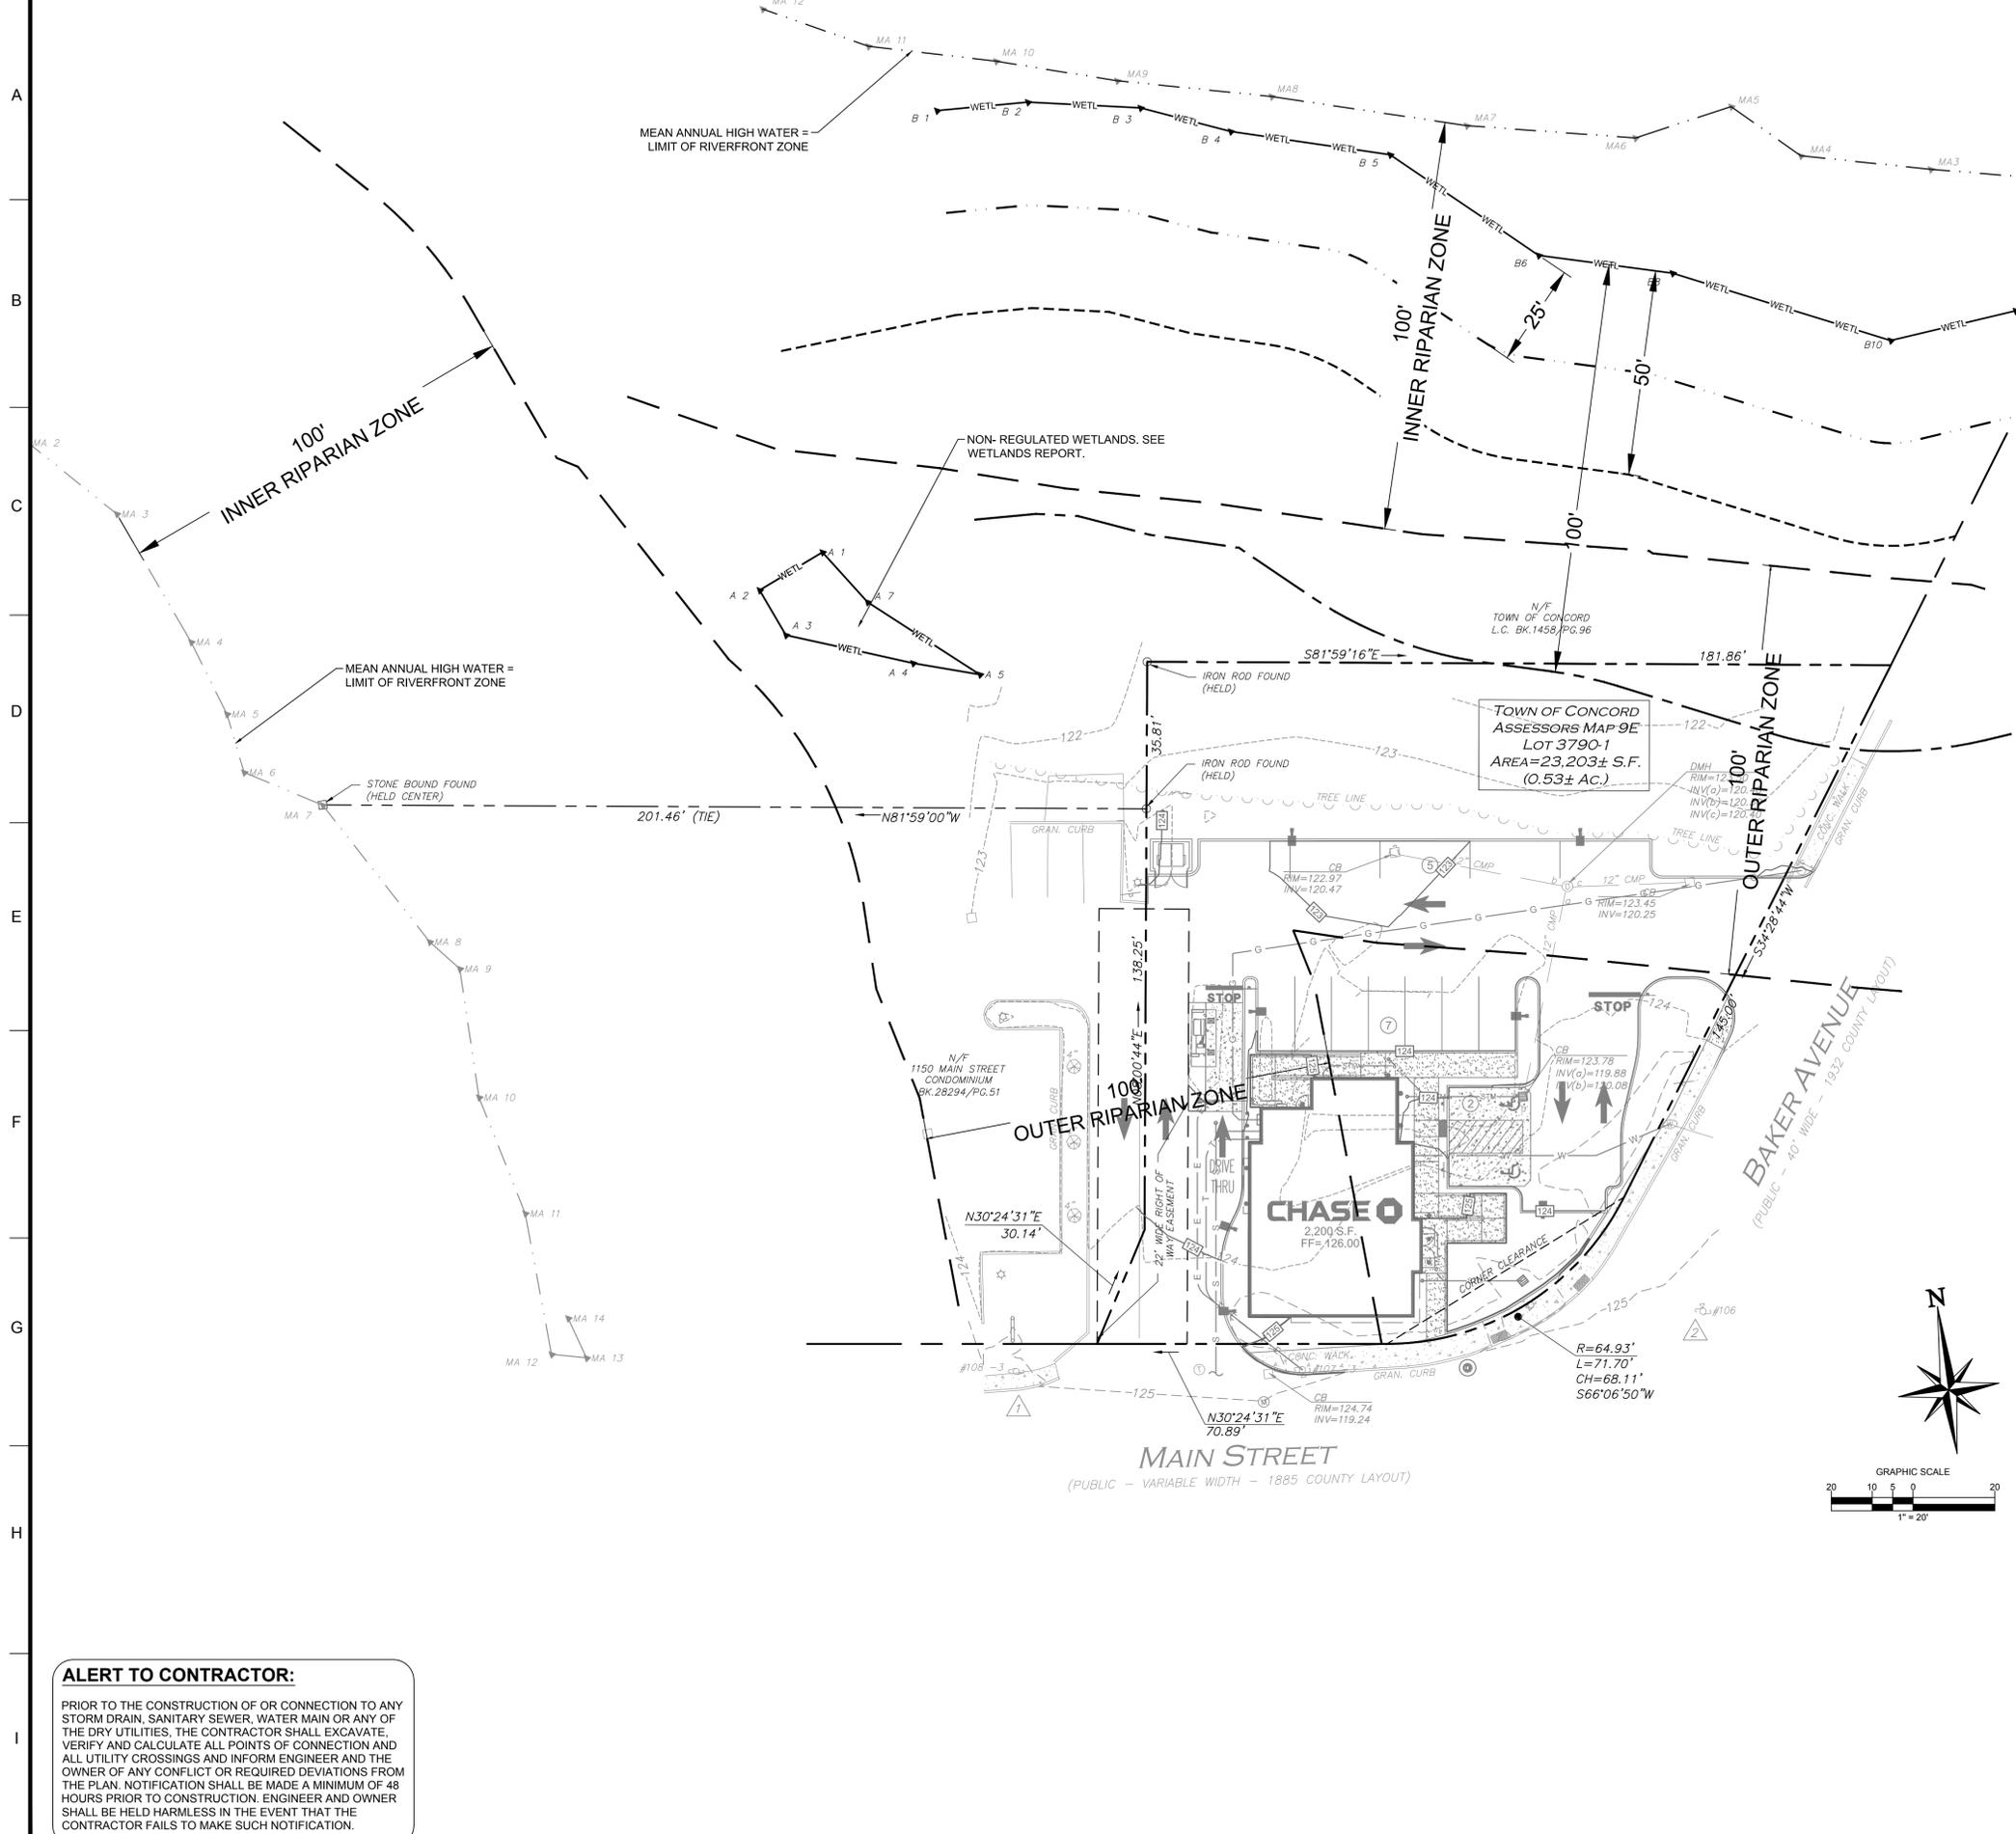

PROPERTY INFORMATION:

THIS DRAWING REFERENCES: 1134 MAIN STREET, TOWN OF CONCORD
 EXISTING CONDITIONS
 PREPARED BY: ALLEN & MAJOR ASSOCIATES, INC.
 100 COMMERCE WAY
 WOBURN, MA 01801
 CONTACT: CHARLES OSBORNE, PLS
 TEL: (732) 422-6700

PROPERTY OWNER: NIKOEL LLC.
 78 RHODE ISLAND AVENUE #3
 NEWPORT, RI 02840

APPLICANT: J.P. MORGAN CHASE BANK
 1450 BRICKELL AVENUE 3RD FLOOR
 MIAMI, FL 33131
 CONTACT: CHRIS FOIT
 TEL: (786) 473-1769

SITE ADDRESS: 1134 MAIN STREET
 CONCORD, MA 01742
 COUNTY OF MIDDLESEX

ZONING DATA: ZONED: WEST CONCORD BUSINESS DISTRICT (WCB)

EXISTING USE: BANK (PERMITTED)
 PROPOSED USE: BANK (PERMITTED)
 DRIVE THROUGH
 (SPECIAL USE APPROVAL - APPROVED BY TOWNSHIP)

NOTE:
 • THE PROPOSED FORMULA BUSINESS USE (CHASE WITH DRIVE-UP ATM) FOR THIS PARCEL LOT MATCHES THE EXISTING FORMULA BUSINESS USE (EXISTING CITIZENS BANK WITH DRIVE-UP ATM) IN THE WEST CONCORD BUSINESS DISTRICT WHERE FORMULA BUSINESSES ARE LIMITED.
 • FLOOD PLAIN ELEVATION IS DESIGNATED AS ELEVATION 125.00'. APPROXIMATE AREA OF FLOOD PLAIN ON PARCEL IS 21,750 SQUARE FEET.
 • TOTAL AREA OF THE PARCEL WITHIN INNER RIPARIAN ZONE = 950 SF
 TOTAL AREA OF THE PARCEL WITHIN OUTER RIPARIAN ZONE = 15,485 SF
 TOTAL AREA OF THE PARCEL ALTERED WITHIN OUTER RIPARIAN ZONE = 9,675 SF

CORE STATES INC.

12700 Herbert Road
 Dallas, TX 75230
 214.377.5660
 www.core-eng.com

DOCUMENTS PREPARED BY CORE STATES, INC. INCLUDING THIS DOCUMENT ARE TO BE USED ONLY FOR THE SPECIFIC PROJECT AND SPECIFIC USE FOR WHICH THEY WERE INTENDED. ANY EXTENSION OF USE TO ANY OTHER PROJECTS, BY OWNER OR BY ANY OTHER PARTY, WITHOUT THE EXPRESSED WRITTEN CONSENT OF CORE STATES, INC. IS DONE UNLAWFULLY AND AT THE USER'S OWN RISK. IF USED IN A WAY OTHER THAN THAT SPECIFICALLY INTENDED, USER WILL HOLD CORE STATES, INC. HARMLESS FROM ALL CLAIMS AND LOSSES.

CLIENT

CHASE

811

Know what's below. Call before you dig.

REVISIONS

REV	DATE	COMMENT	BY
1	06/01/20	REVISED PER TOWNSHIP COMMENTS	KGF

DOCUMENT SITE PLAN APPROVAL FOR CHASE BANK

SITE LOCATION
 MAIN STREET & BAKER AVENUE
 1134 MAIN STREET
 CONCORD, MA 01742

ENGINEER SEAL


ALAN D. ROSCOE, P.E.
 MA LICENSE #40163
 SHEET TITLE
 WETLANDS BUFFER PLAN

JOB #: JPM-27599
 DATE: 04/28/2020
 SCALE: 1" = 20'
 DRAWN BY: CC
 CHECKED BY: TP

SHEET NO.
C-7


WETLANDS BUFFER PLAN LEGEND

	EXISTING PROPERTY BOUNDARY LINE
	EXISTING ADJOINING PROPERTY LINE
	EXISTING CURB
	PROPOSED CURB
	PROPOSED MOUNTABLE
	PROPOSED BUILDING
	PROPOSED CONCRETE
	LIMITS OF DISTURBANCE
	LIMITS OF DISTURBANCE HATCH
	25 FOOT WETLAND NO DISTURB ZONE
	50 FOOT WETLAND NO BUILD ZONE
	100 FOOT WETLAND BUFFER ZONE
	100 FOOT WETLAND BUFFER ZONE
	WETLANDS BOUNDARY
	MEAN ANNUAL HIGHWATER
	WETLANDS FLAG
	PROPOSED PARKING COUNT
	EXISTING 5' INTERVAL CONTOUR LINE
	EXISTING 1' INTERVAL CONTOUR LINE
	PROPOSED 5' INTERVAL CONTOUR LINE
	PROPOSED 1' INTERVAL CONTOUR LINE
	SILT FENCE
	SILT SOXX
	TREE PROTECTION

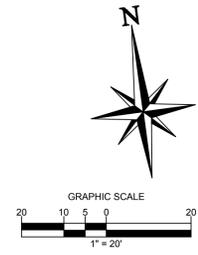

ALERT TO CONTRACTOR:

PRIOR TO THE CONSTRUCTION OF OR CONNECTION TO ANY STORM DRAIN, SANITARY SEWER, WATER MAIN OR ANY OF THE DRY UTILITIES, THE CONTRACTOR SHALL EXCAVATE, VERIFY AND CALCULATE ALL POINTS OF CONNECTION AND ALL UTILITY CROSSINGS AND INFORM ENGINEER AND THE OWNER OF ANY CONFLICT OR REQUIRED DEVIATIONS FROM THE PLAN. NOTIFICATION SHALL BE MADE A MINIMUM OF 48 HOURS PRIOR TO CONSTRUCTION. ENGINEER AND OWNER SHALL BE HELD HARMLESS IN THE EVENT THAT THE CONTRACTOR FAILS TO MAKE SUCH NOTIFICATION.

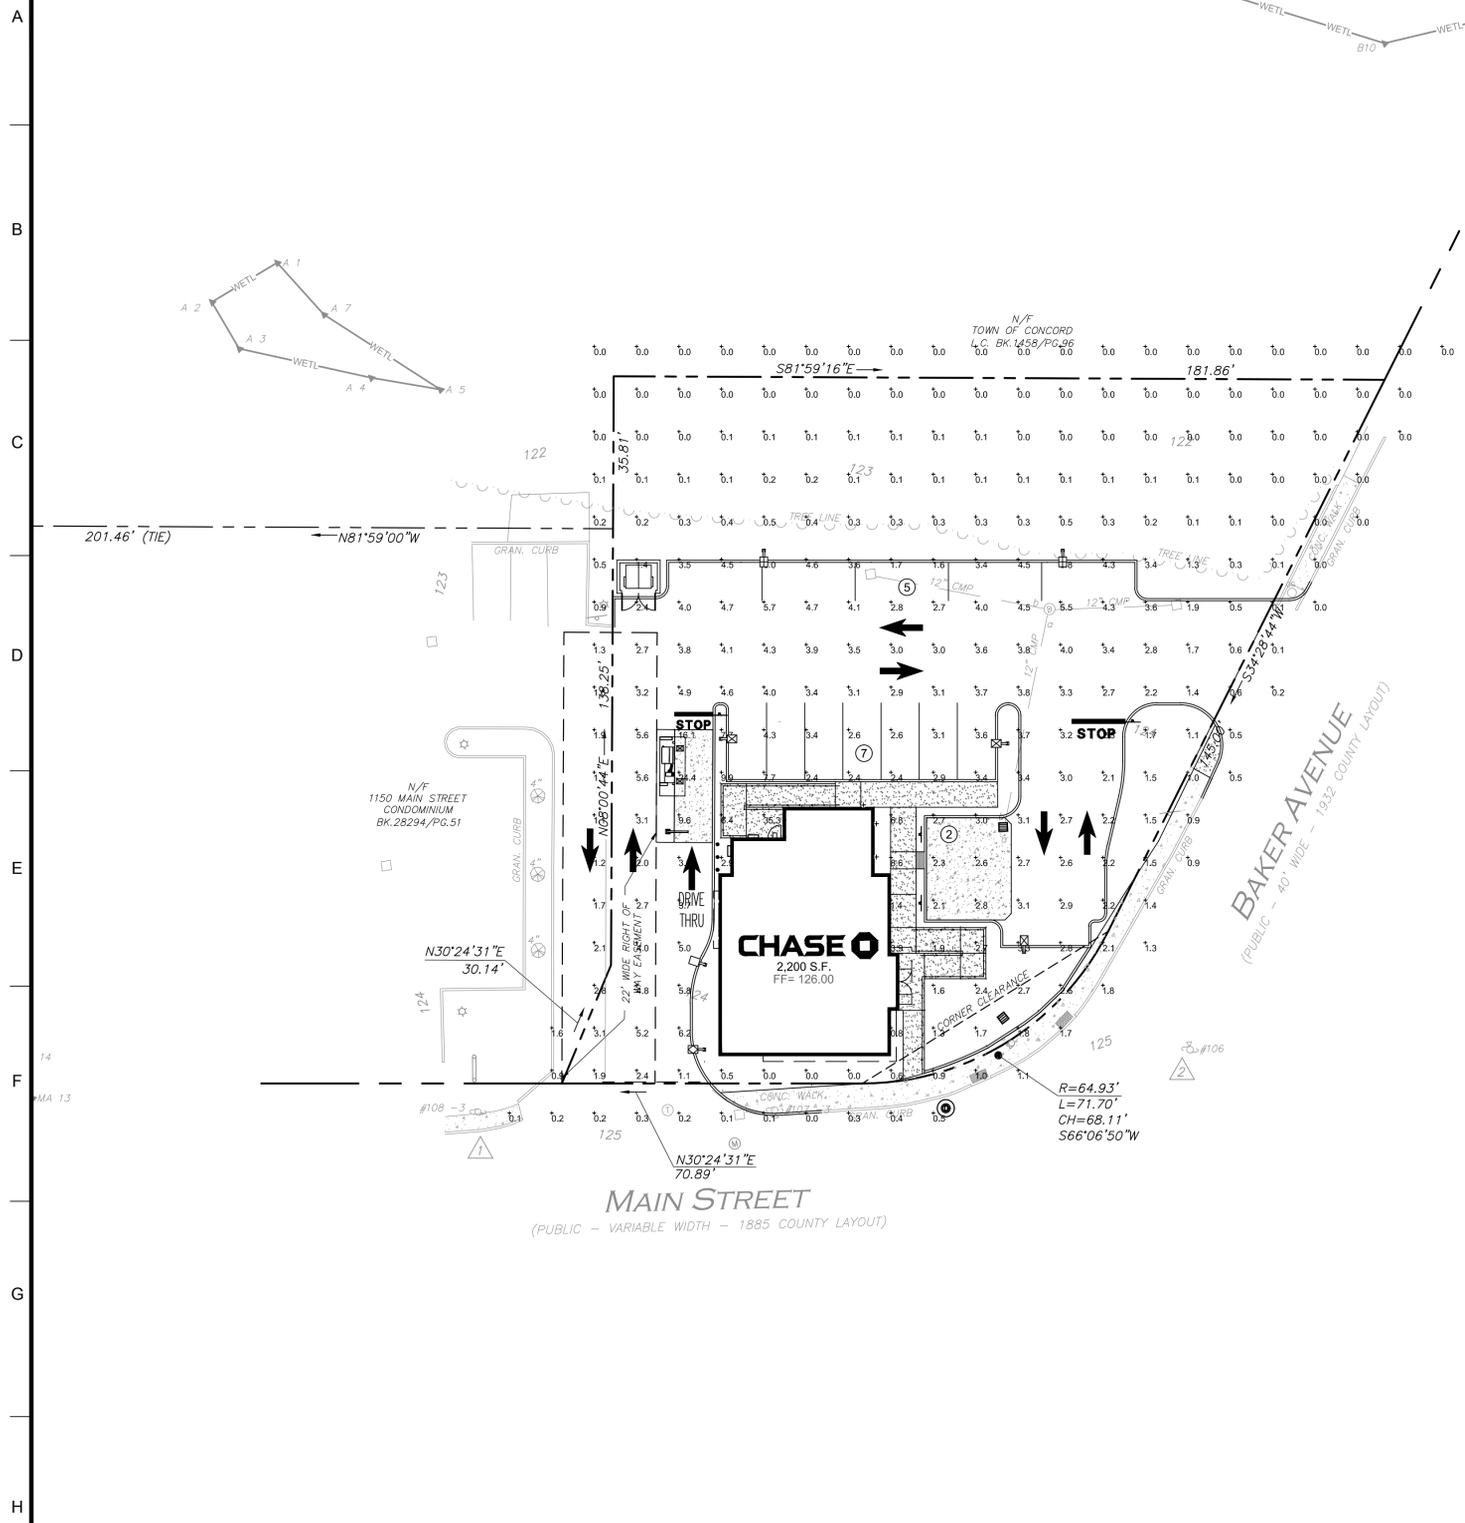


LUMINAIRE SCHEDULE						
SYMBOL	MANUFACTURER	MODEL	CATALOG	QTY	DISTRIBUTION	MOUNT HT.
☒	E-CONLIGHT	LED SQUARE CANOPY	E-CSA04A-W50W	2	TYPE 5	10'-0"
■	LUMARK	CROSSTOUR LED	XTOR6B-W-BZ-MS/DIM-L20-CPB	1	TYPE 3	10'-0"
●	AMERLUX	ROUND LENSED DOWN LIGHT	HDL-HP-R-A17-65SOL-3000	5	TYPE 5	10'-0"
⊕	EATON	LANTERRA 9004	9004-W2-RW-LED-3090-W-BK-L1-UNV	3	TYPE 5	10'-0"
☒	MCGRAW EDISON	GLEON GALLEON LED	GLEON-AF-01-LED-E1-SLR-7030	1	TYPE 90° SPILL LIGHT ELIMINATOR RIGHT	18'-0"
☒	MCGRAW EDISON	GLEON GALLEON LED	GLEON-AF-01-LED-E1-SL4-7030-HSS	1	TYPE 4	18'-0"
☒	MCGRAW EDISON	GLEON GALLEON LED	GLEON-AF-02-LED-E1-SL4-7030	2	TYPE 4	18'-0"
☒	MCGRAW EDISON	GLEON GALLEON LED	GLEON-AF-02-LED-E1-5WQ-7030	3	TYPE 5	18'-0"


CALCULATION SUMMARY			
AREA	AVERAGE	MAX	MIN
PROPERTY ANALYSIS @ 3-FT ABOVE GRADE	2.48 fc	35.3 fc	0.0 fc

- LIGHTING NOTES**
1. LIGHT ANALYSIS CONDUCTED AT 3-FT ABOVE GRADE.
 2. ALL PROPOSED FIXTURES ON TIMER TO OPERATE DURING NIGHT TIME HOURS, 30 MINUTES AFTER SUNSET AND 30 MINUTES BEFORE SUNRISE.
 3. CONTRACTOR TO INSTALL FIXTURE ON COPPER LIGHTING POLE RSS-6-A-XX-S-Y-N-XX. MOUNT HEIGHTS ARE BASED ON HEIGHT ABOVE FINISHED ASPHALT GRADE.

- LIGHTING LEGEND**
- EXISTING PROPERTY BOUNDARY LINE
 - - - EXISTING ADJOINING PROPERTY LINE
 - - - EXISTING ROAD CENTERLINE
 - PROPOSED CURB
 - EXISTING CURB
 - 1.9 FOOTCANDLE CALCULATION POINT
 - ☒ PROPOSED SITE LIGHT FIXTURE

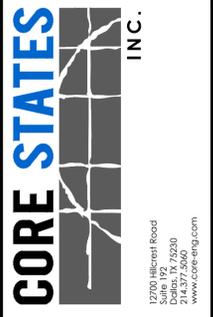

DOCUMENTS PREPARED BY CORE STATES, INC. INCLUDING THIS DOCUMENT ARE TO BE USED ONLY FOR THE SPECIFIC PROJECT AND SPECIFIC USE FOR WHICH THEY WERE INTENDED. ANY EXTENSION OF USE TO ANY OTHER PROJECTS, BY OWNER OR BY ANY OTHER PARTY, WITHOUT THE EXPRESSED WRITTEN CONSENT OF CORE STATES, INC. IS DONE UNLAWFULLY AND AT THE USER'S OWN RISK. IT IS USED IN A WAY OTHER THAN THAT SPECIFICALLY INTENDED. USER WILL HOLD CORE STATES, INC. HARMLESS FROM ALL CLAIMS AND LOSSES.

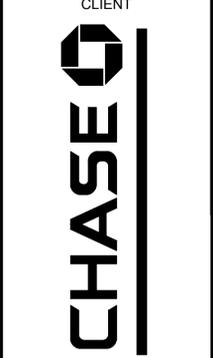

Know what's below. Call before you dig. The CONTRACTOR is specifically cautioned that the location and/or location of existing utilities as shown on these drawings is based on records and field verification. CORE STATES, INC. DOES NOT GUARANTEE THE LOCATION AND DEPTH OF UTILITIES. THE CONTRACTOR SHALL VERIFY THE LOCATION AND DEPTH OF UTILITIES PRIOR TO ANY EXCAVATION.

REV	DATE	COMMENT	BY
1	06/01/20	REVISED PER TOWNSHIP COMMENTS	KGF

DOCUMENT SITE PLAN APPROVAL FOR CHASE BANK

SITE LOCATION
 MAIN STREET & BAKER AVENUE
 1134 MAIN STREET
 CONCORD, MA 01742

ENGINEER SEAL

ALAN D. ROSCOE, P.E.
 MA LICENSE #40163


SHEET TITLE
 LIGHTING PLAN

JOB #:	JPM-27599
DATE:	04/28/2020
SCALE:	AS SHOWN
DRAWN BY:	CC
CHECKED BY:	TP

SHEET NO.
C-8

ALERT TO CONTRACTOR:

PRIOR TO THE CONSTRUCTION OF OR CONNECTION TO ANY STORM DRAIN, SANITARY SEWER, WATER MAIN OR ANY OF THE DRY UTILITIES, THE CONTRACTOR SHALL EXCAVATE, VERIFY AND CALCULATE ALL POINTS OF CONNECTION AND ALL UTILITY CROSSINGS AND INFORM ENGINEER AND THE OWNER OF ANY CONFLICT OR REQUIRED DEVIATIONS FROM THE PLAN. NOTIFICATION SHALL BE MADE A MINIMUM OF 48 HOURS PRIOR TO CONSTRUCTION. ENGINEER AND OWNER SHALL BE HELD HARMLESS IN THE EVENT THAT THE CONTRACTOR FAILS TO MAKE SUCH NOTIFICATION.

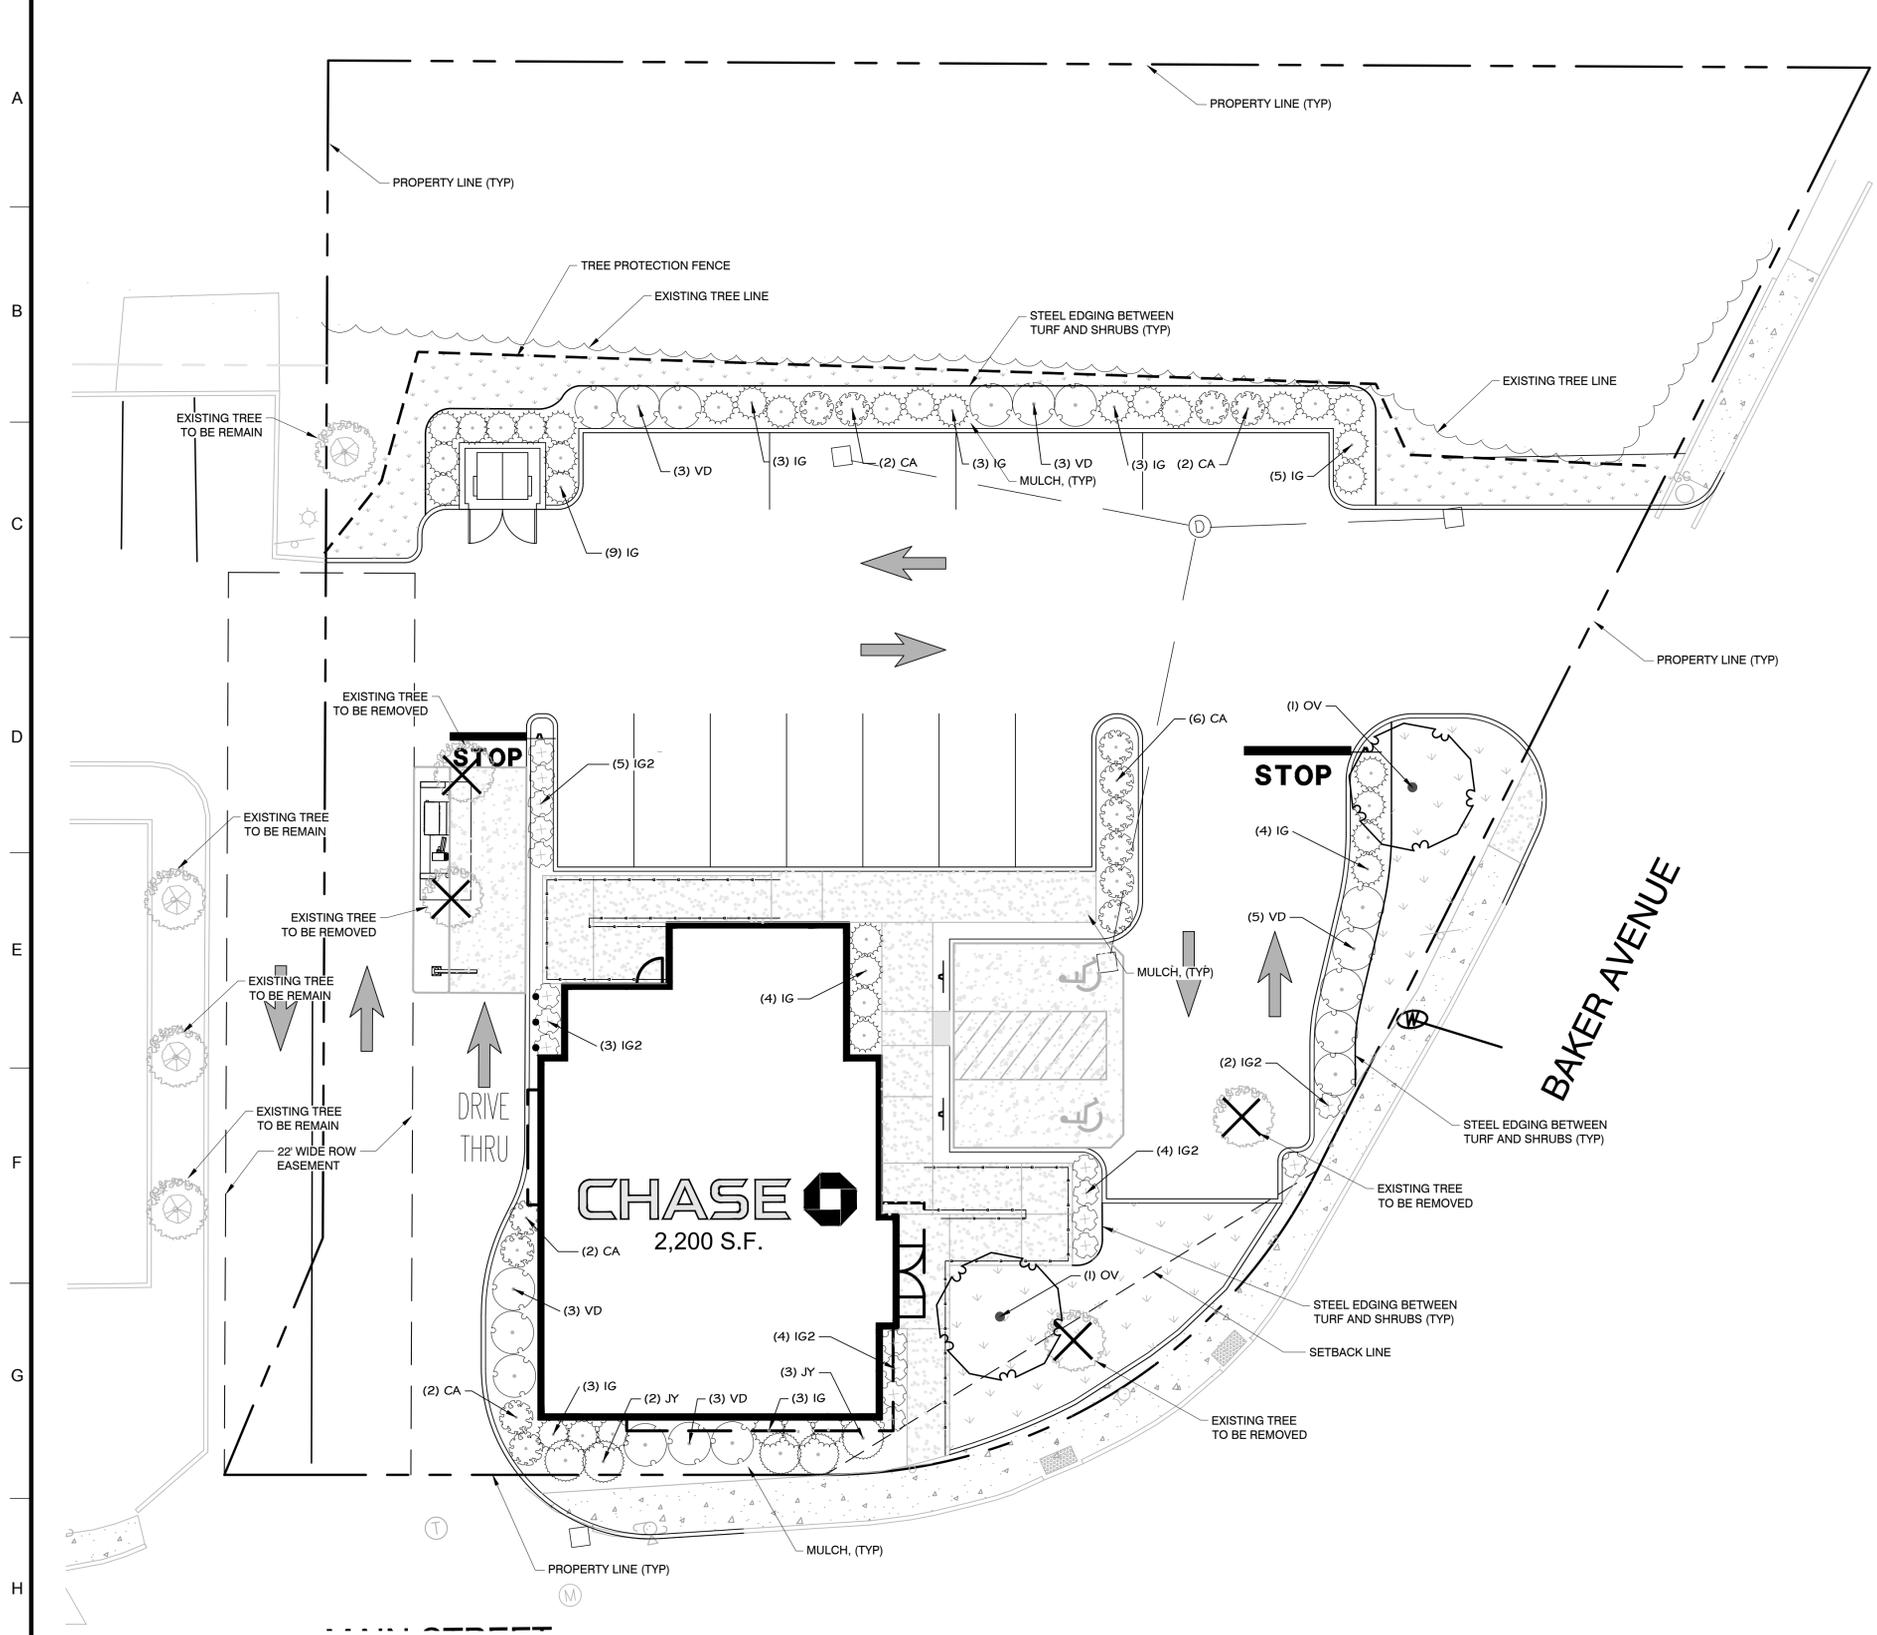

PLANT SCHEDULE

TREES	CODE	BOTANICAL / COMMON NAME	CAL	CONT.	SIZE	QTY
	OV	Ostrya virginiana American Hophornbeam	3" Cal.	B&B	10'-12'	2
SHRUBS	CODE	BOTANICAL / COMMON NAME	CONTAINER	SIZE	SPACING	QTY
	CA	Clethra alnifolia 'Hummingbird' Summersweet	5 gal.		2'-4'	14
	IG	Ilex glabra 'Shamrock' Inkberry	5 gal.		3'-4'	37
	IG2	Ilex glabra 'SMNIGAB17' TM Gem Box Inkberry Holly	3 gal.		2'-3'	18
	JY	Juniperus horizontalis 'Youngstown' Creeping Juniper	5 gal.		6'-1'	5
	VD	Viburnum dentatum 'Arrowwood' Arrowwood Viburnum	5 gal.		6'-8'	17
GROUND COVERS	CODE	BOTANICAL / COMMON NAME	CONT.	SIZE	SPACING	QTY
	TURF	Poa pratensis Kentucky Bluegrass	sod			1,653 sf

GENERAL GRADING AND PLANTING NOTES

- BY SUBMITTING A PROPOSAL FOR THE LANDSCAPE PLANTING SCOPE OF WORK, THE CONTRACTOR CONFIRMS THAT HE HAS READ AND WILL COMPLY WITH THE ASSOCIATED NOTES, SPECIFICATIONS, AND DETAILS WITH THIS PROJECT.
- THE GENERAL CONTRACTOR IS RESPONSIBLE FOR REMOVING ALL EXISTING VEGETATION (EXCEPT WHERE NOTED TO REMAIN).
- IN THE CONTEXT OF THESE PLANS, NOTES, AND SPECIFICATIONS, "FINISH GRADE" REFERS TO THE FINAL ELEVATION OF THE SOIL SURFACE (NOT TOP OF MULCH) AS INDICATED ON THE GRADING PLANS.
 - BEFORE STARTING WORK, THE LANDSCAPE CONTRACTOR SHALL VERIFY THAT THE ROUGH GRADES OF ALL LANDSCAPE AREAS ARE WITHIN +/-0.1' OF FINISH GRADE. SEE SPECIFICATIONS FOR MORE DETAILED INSTRUCTION ON TURF AREA AND PLANTING BED PREPARATION.
 - CONSTRUCT AND MAINTAIN FINISH GRADES AS SHOWN ON GRADING PLANS, AND CONSTRUCT AND MAINTAIN SLOPES AS RECOMMENDED BY THE GEOTECHNICAL REPORT. ALL LANDSCAPE AREAS SHALL HAVE POSITIVE DRAINAGE AWAY FROM STRUCTURES AT THE MINIMUM SLOPE SPECIFIED IN THE REPORT AND ON THE GRADING PLANS, AND AREAS OF POTENTIAL PONDING SHALL BE REGRADED TO BLEND IN WITH THE SURROUNDING GRADES AND ELIMINATE PONDING POTENTIAL.
 - THE LANDSCAPE CONTRACTOR SHALL DETERMINE WHETHER OR NOT THE EXPORT OF ANY SOIL WILL BE NEEDED, TAKING INTO ACCOUNT THE ROUGH GRADE PROVIDED, THE AMOUNT OF SOIL AMENDMENTS TO BE ADDED (BASED ON A SOIL TEST, PER SPECIFICATIONS), AND THE FINISH GRADES TO BE ESTABLISHED.
 - ENSURE THAT THE FINISH GRADE IN SHRUB AREAS IMMEDIATELY ADJACENT TO WALKS AND OTHER WALKING SURFACES, AFTER INSTALLING SOIL AMENDMENTS, IS 2" BELOW THE ADJACENT FINISH SURFACE, IN ORDER TO ALLOW FOR PROPER MULCH DEPTH. TAPER THE SOIL SURFACE TO MEET FINISH GRADE, AS SPECIFIED ON THE GRADING PLANS, AT APPROXIMATELY 18" AWAY FROM THE WALKS.
 - ENSURE THAT THE FINISH GRADE IN TURF AREAS IMMEDIATELY ADJACENT TO WALKS AND OTHER WALKING SURFACES, AFTER INSTALLING SOIL AMENDMENTS, IS 1" BELOW THE FINISH SURFACE OF THE WALKS. TAPER THE SOIL SURFACE TO MEET FINISH GRADE, AS SPECIFIED ON THE GRADING PLANS, AT APPROXIMATELY 18" AWAY FROM THE WALKS.
 - SHOULD ANY CONFLICTS AND/OR DISCREPANCIES ARISE BETWEEN THE GRADING PLANS, GEOTECHNICAL REPORT, THESE NOTES AND PLANS, AND ACTUAL CONDITIONS, THE CONTRACTOR SHALL IMMEDIATELY BRING SUCH ITEMS TO THE ATTENTION OF THE LANDSCAPE ARCHITECT, GENERAL CONTRACTOR, AND OWNER.
- ALL PLANT LOCATIONS ARE DIAGRAMMATIC. ACTUAL LOCATIONS SHALL BE VERIFIED WITH THE LANDSCAPE ARCHITECT OR DESIGNER PRIOR TO PLANTING. THE LANDSCAPE CONTRACTOR SHALL ENSURE THAT ALL REQUIREMENTS OF THE PERMITTING AUTHORITY ARE MET (I.E., MINIMUM PLANT QUANTITIES, PLANTING METHODS, TREE PROTECTION METHODS, ETC.).
 - THE LANDSCAPE CONTRACTOR IS RESPONSIBLE FOR DETERMINING PLANT QUANTITIES; PLANT QUANTITIES SHOWN ON LEGENDS AND CALLOUTS ARE FOR GENERAL INFORMATION ONLY. IN THE EVENT OF A DISCREPANCY BETWEEN THE PLAN AND THE PLANT LEGEND, THE PLANT QUANTITY AS SHOWN ON THE PLAN (FOR INDIVIDUAL SYMBOLS) OR CALLOUT (FOR GROUNDCOVER PATTERNS) SHALL TAKE PRECEDENCE.
 - NO SUBSTITUTIONS OF PLANT MATERIALS SHALL BE ALLOWED WITHOUT THE WRITTEN PERMISSION OF THE LANDSCAPE ARCHITECT. IF SOME OF THE PLANTS ARE NOT AVAILABLE, THE LANDSCAPE CONTRACTOR SHALL NOTIFY THE LANDSCAPE ARCHITECT IN WRITING (VIA PROPER CHANNELS).
 - THE CONTRACTOR SHALL, AT A MINIMUM, PROVIDE REPRESENTATIVE PHOTOS OF ALL PLANTS PROPOSED FOR THE PROJECT. THE CONTRACTOR SHALL ALLOW THE LANDSCAPE ARCHITECT AND THE OWNER/OWNER'S REPRESENTATIVE TO INSPECT, AND APPROVE OR REJECT, ALL PLANTS DELIVERED TO THE JOBSITE. REFER TO SPECIFICATIONS FOR ADDITIONAL REQUIREMENTS FOR SUBMITTALS.
- THE CONTRACTOR SHALL MAINTAIN THE LANDSCAPE IN A HEALTHY CONDITION FOR 90 DAYS AFTER ACCEPTANCE BY THE OWNER. REFER TO SPECIFICATIONS FOR CONDITIONS OF ACCEPTANCE FOR THE START OF THE MAINTENANCE PERIOD, AND FOR FINAL ACCEPTANCE AT THE END OF THE MAINTENANCE PERIOD.
- SEE SPECIFICATIONS AND DETAILS FOR FURTHER REQUIREMENTS.

LEGEND

- EXISTING TREE TO PROTECT IN PLACE
- EXISTING TREE TO REMOVE
- TREE PROTECTIVE FENCING

NOTE: SEE SHEET LP-3 FOR DETAILS AND SPECIFICATIONS

1270 Hibernia Road
Dorset, MA 01920
314.377.5660
www.corestateseng.com

DOCUMENTS PREPARED BY CORE STATES, INC. INCLUDING THIS DOCUMENT, ARE TO BE USED ONLY FOR THE SPECIFIC PROJECT AND SPECIFIC USE FOR WHICH THEY WERE INTENDED. ANY EXTENSION OF USE TO ANY OTHER PROJECTS, BY OWNER OR BY ANY OTHER PARTY, WITHOUT THE EXPRESS WRITTEN CONSENT OF CORE STATES, INC. IS DONE UNLAWFULLY AND AT THE USER'S OWN RISK. IT IS USED IN A WAY OTHER THAN THAT SPECIFICALLY INTENDED. USER WILL HOLD CORE STATES, INC. HARMLESS FROM ALL CLAIMS AND LOSSES.

CLIENT

Know what's below. Call before you dig.

THE CONTRACTOR IS SPECIFICALLY CAUTIONED THAT THE LOCATION AND DEPTH OF EXISTING UTILITIES SHOWN ON THESE PLANS ARE BASED ON DESIGN INFORMATION TAKEN IN THE FIELD. CORE STATES, INC. DOES NOT GUARANTEE THE LOCATION OR DEPTH OF EXISTING UTILITIES. THE CONTRACTOR SHALL VERIFY THE LOCATION AND DEPTH OF UTILITIES AT THE JOBSITE PRIOR TO ANY CONSTRUCTION.

REV	DATE	COMMENT	BY

DOCUMENT
SITE PLAN
APPROVAL FOR
CHASE BANK

SITE LOCATION
MAIN STREET &
BAKER AVENUE
1134 MAIN STREET
CONCORD, MA 01742

ENGINEER SEAL

ALAN D. ROSCOE, P.E.
MA LICENSE #40163
SHEET TITLE

LANDSCAPE
PLANTING

JOB #: JPM-27599
DATE: 05/04/2020
SCALE:
DRAWN BY: EMS
CHECKED BY: RM


SHEET NO.

LP-1


Scale 1" = 10'

1200 US Highway 22 E. Suite 2000-2248
Bridgewater, NJ 08807
www.EvergreenDesignGroup.com


A
B
C
D
E
F
G
H
I

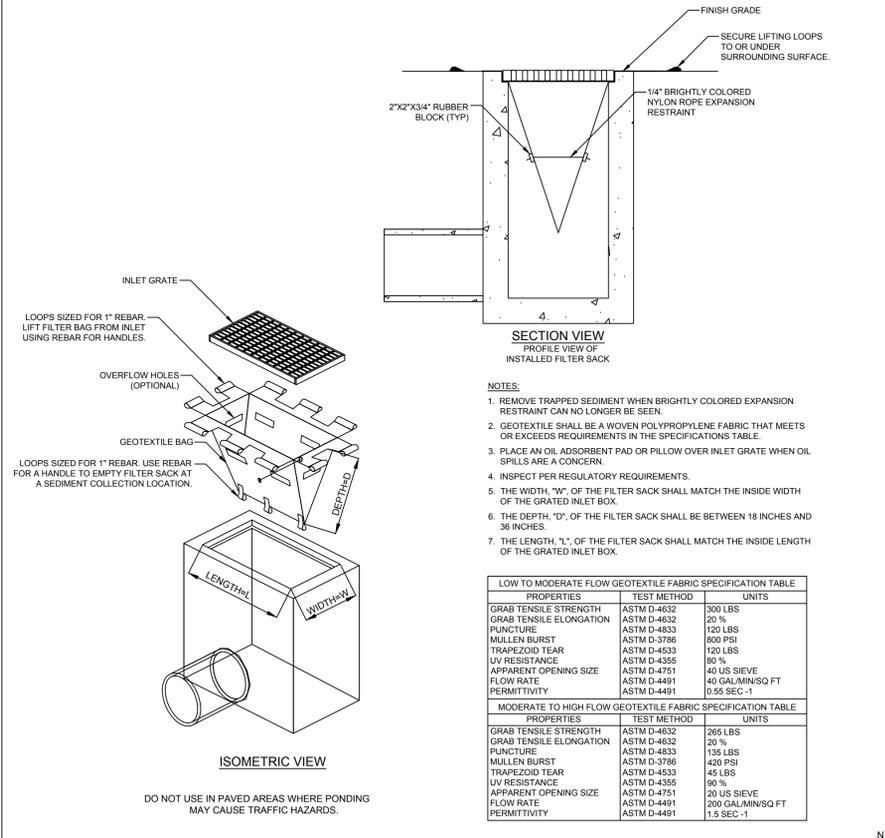


FILTER SACKS - INLET PROTECTION (IP-1)

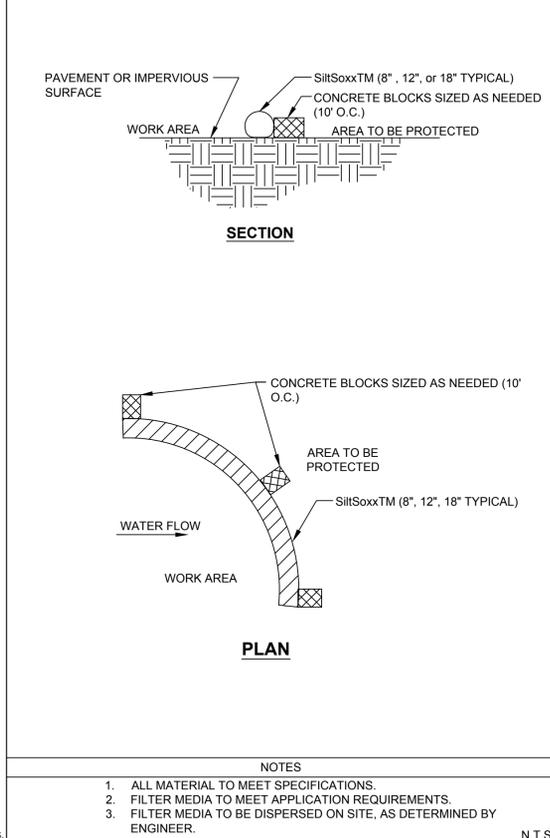


SILT SOXX ON PAVEMENT (SS)

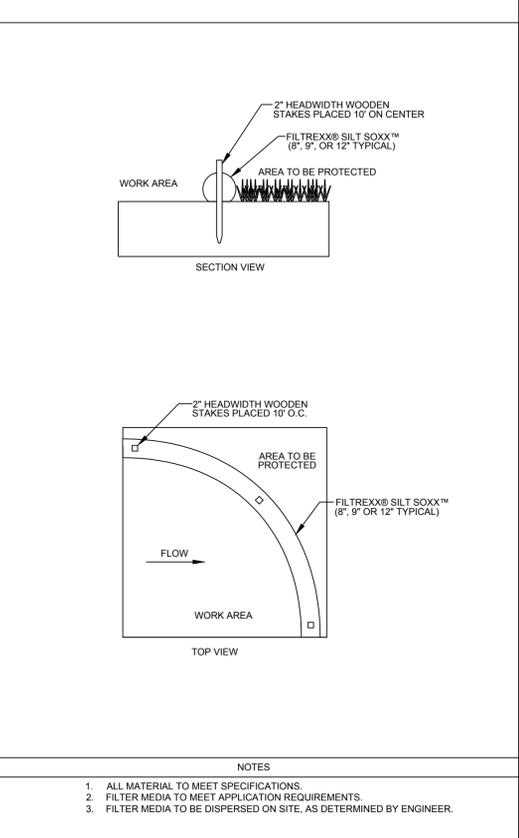


SILT SOXX ON TURF (SS)

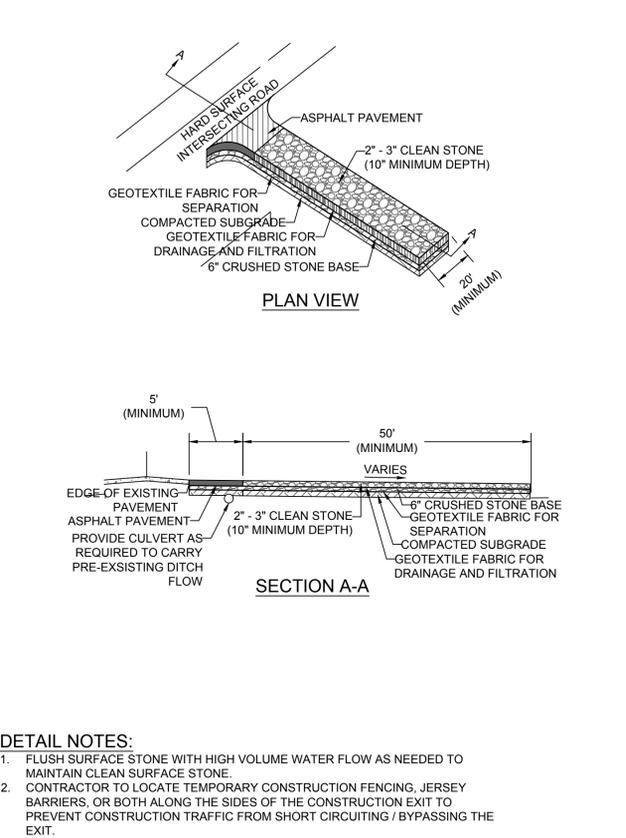


CONSTRUCTION EXIT (CE)

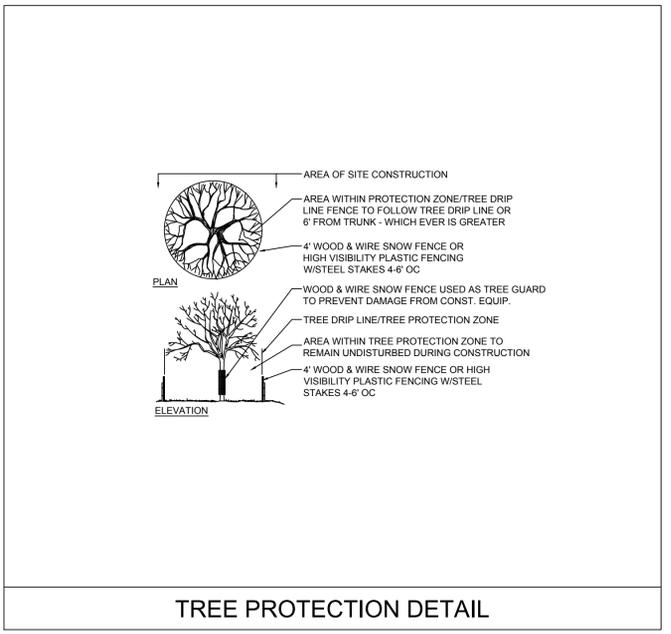

TREE PROTECTION DETAIL

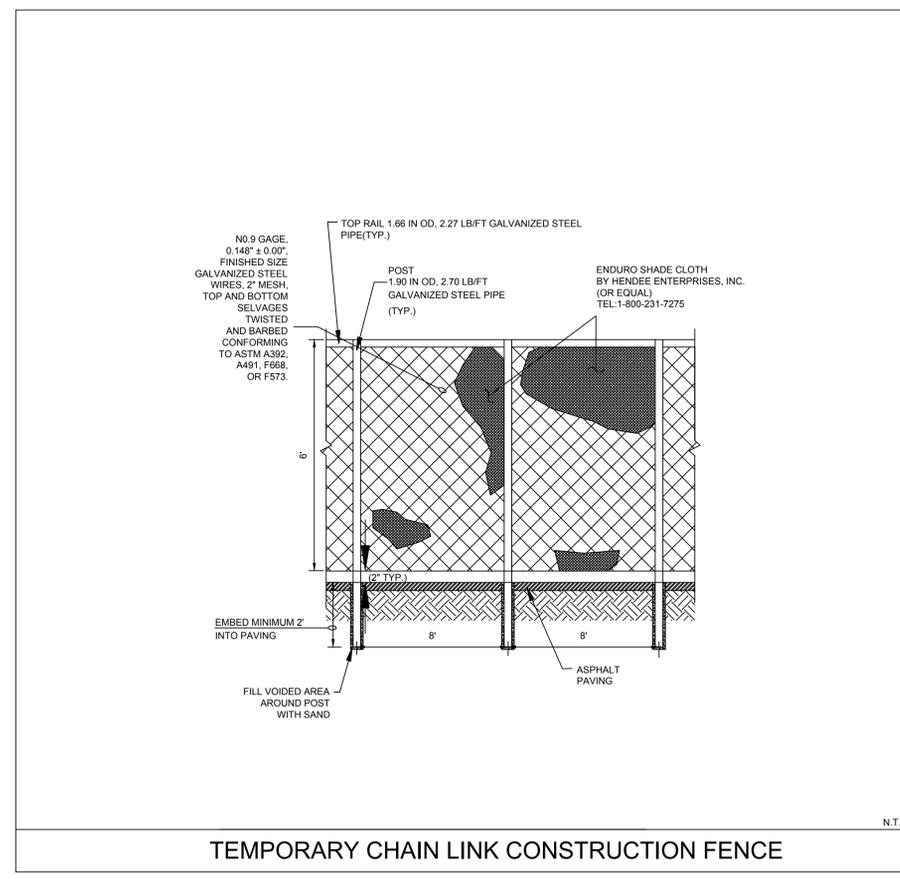

TEMPORARY CHAIN LINK CONSTRUCTION FENCE

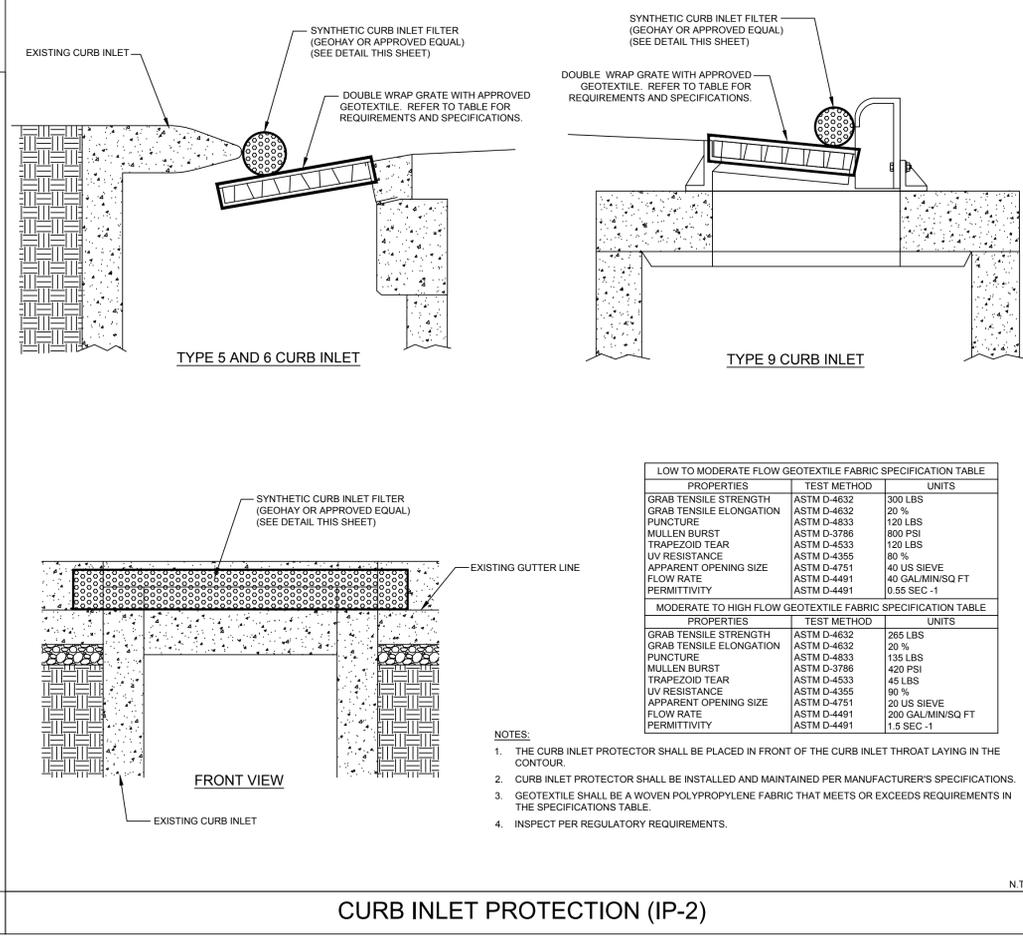

CURB INLET PROTECTION (IP-2)

CORE STATES INC.
1270 Haverhill Road
Dorset, MA 01920
508.377.5600
www.core-states-inc.com

DOCUMENTS PREPARED BY CORE STATES, INC. INCLUDING THIS DOCUMENT ARE TO BE USED ONLY FOR THE SPECIFIC PROJECT AND SPECIFIC USE FOR WHICH THEY WERE INTENDED. ANY EXTENSION OF USE TO ANY OTHER PROJECTS, BY OWNER OR BY ANY OTHER PARTY, WITHOUT THE EXPRESSED WRITTEN CONSENT OF CORE STATES, INC. IS DONE UNLAWFULLY AND AT THE USER'S OWN RISK. IT IS USED IN A WAY OTHER THAN THAT SPECIFICALLY INTENDED, USER WILL HOLD CORE STATES, INC. HARMLESS FROM ALL CLAIMS AND LOSSES.

CHASE

CLIENT

Know what's below. Call before you dig.
The contractor is specifically cautioned that the location and/or location of existing utilities is shown on these drawings based on current information known in the field. CORE STATES, INC. DOES NOT GUARANTEE THE LOCATION AND DEPTH OF UTILITIES SHOWN ON THESE DRAWINGS. THE USER SHALL VERIFY THE LOCATION AND DEPTH OF UTILITIES PRIOR TO ANY CONSTRUCTION.

REV	DATE	COMMENT	BY
1	06/01/20	REVISED PER TOWNSHIP COMMENTS	KGF

DOCUMENT SITE PLAN APPROVAL FOR CHASE BANK

SITE LOCATION
MAIN STREET & BAKER AVENUE
1134 MAIN STREET
CONCORD, MA 01742

ENGINEER SEAL

ALAN D. ROSCOE, P.E.
MA LICENSE #40163

SHEET TITLE
EROSION CONTROL DETAILS

JOB #: JPM-27599
DATE: 04/28/2020
SCALE: AS SHOWN
DRAWN BY: CC
CHECKED BY: TP

SHEET NO.
CD-1

GENERAL

THIS PLAN PROPOSES EROSION CONTROL MEASURES TO ADEQUATELY CONTROL ACCELERATED SEDIMENTATION AND REDUCE THE DANGER FROM STORM WATER RUNOFF AT THE SITE. THE RUNOFF SHALL BE CONTROLLED BY THE INTERCEPTION, DIVERSION, AND SAFE DISPOSAL OF PRECIPITATION. RUNOFF SHALL ALSO BE CONTROLLED BY STAGING CONSTRUCTION ACTIVITY AND PRESERVING NATURAL VEGETATION WHEREVER POSSIBLE.

EXISTING VEGETATION SHALL BE PROTECTED AND ONLY THAT CLEARING AND GRUBBING ABSOLUTELY NECESSARY TO THE PROPOSED CONSTRUCTION SHALL BE PERFORMED. ALL DISTURBED AREAS SHALL BE RESTORED TO THEIR ORIGINAL CONDITION AND CONTOUR, UNLESS OTHERWISE INDICATED ON THE PLANS. THE CONTRACTOR SHALL TAKE SPECIAL CARE WITH HIS CONSTRUCTION METHODS AND SHALL COMPLY WITH THE FOLLOWING GUIDELINES.

SEDIMENTATION CONTROL

ALL AREAS SHALL BE PROTECTED FROM SEDIMENTATION DURING AND AFTER CONSTRUCTION, PARTICULARLY THE STORAGE OF EXCAVATED OR STOCKPILED MATERIAL. THE CONTRACTOR SHALL CAREFULLY STRIP ALL TOPSOIL, LOAM, OR ORGANIC MATTER PRIOR TO THE TRENCHING OR OTHER OPERATIONS AND SHALL STORE THEM SEPARATELY FROM ALL OTHER MATERIALS DURING EXCAVATION. EACH STOCKPILE MUST BE ADEQUATELY RINGED WITH SEDIMENT CONTROL MATERIAL (I.E. HAY BALES AND/OR FILTER FIBER ROLL).

DEBRIS AND OTHER WASTE RESULTING FROM EQUIPMENT MAINTENANCE AND CONSTRUCTION WILL NOT BE DISCARDED ON SITE.

EROSION AND SEDIMENTATION CONTROL PLAN

SEDIMENTATION CONTROL SYSTEM - THE SEDIMENTATION CONTROL SYSTEM SHALL CONSIST OF FILTER FABRIC BARRIER FENCE & HAYBALES. THE SEDIMENTATION CONTROL SYSTEM SHALL BE INSTALLED IMMEDIATELY AFTER A CUT SLOPE HAS BEEN GRADED, BEFORE A FILL SLOPE HAS BEEN CREATED AND AS INDICATED ON THE PLANS. THE SYSTEM DESIGNED TO INTERCEPT SILT AND SEDIMENT BEFORE IT REACHES THE WETLANDS OR WATERCOURSES. DEPOSITS OF SEDIMENT AND SILT ARE TO BE PERIODICALLY REMOVED FOR THE UPSTREAM SIDE OF THE FENCE. THIS MATERIAL IS TO BE SPREAD AND STABILIZED IN AREAS NOT SUBJECT TO EROSION, OR IN AREAS WHICH ARE NOT TO BE PAVED OR BUILT ON. THE SEDIMENTATION CONTROL SYSTEM IS TO BE REPLACED AS NECESSARY TO PROVIDE PROPER FILTERING ACTION. THE SYSTEM IS TO REMAIN IN PLACE AND BE MAINTAINED TO INSURE EFFICIENT SILTATION CONTROL UNTIL ALL AREAS ABOVE THE SYSTEM ARE STABILIZED AND VEGETATION HAS BEEN ESTABLISHED.

STACKED HAY BALES - HAY OR STRAW BALES USED FOR EROSION CONTROL SHALL BE STACKED AT CATCH BASINS WHERE SEDIMENT MAY ENTER THE CATCH BASIN OR AS DIRECTED BY THE RESIDENT ENGINEER. DEPOSITS OF SEDIMENT AND SILT ARE TO BE PERIODICALLY REMOVED FROM THE UPSTREAM SIDE OF THE EROSION CHECKS. THIS MATERIAL IS TO BE SPREAD AND STABILIZED IN AREAS NOT SUBJECT TO EROSION, OR IN AREAS WHICH ARE NOT TO BE PAVED OR BUILT ON. HAY OR STRAW BALES ARE TO BE REPLACED AS NECESSARY TO PROVIDE PROPER FILTERING ACTION. THE SYSTEM IS TO REMAIN IN PLACE AND BE MAINTAINED TO INSURE EFFICIENT SILTATION CONTROL UNTIL ALL AREAS ABOVE THE EROSION CHECKS ARE STABILIZED AND VEGETATION HAS BEEN ESTABLISHED.

EROSION CONTROL MATTING - MATTING SHALL BE USED FOR EROSION CONTROL ON SLOPES GREATER THAN 3:1. SOIL ON SLOPES SHALL BE PREPARED BEFORE INSTALLING MATTING, INCLUDING ANY NECESSARY APPLICATION OF LIME, FERTILIZER AND SEED. THE SYSTEM IS TO REMAIN IN PLACE AND BE MAINTAINED TO INSURE EFFICIENT EROSION CONTROL UNTIL VEGETATION HAS ESTABLISHED.

IN ALL AREAS, REMOVAL OF TREES, BUSHES, AND OTHER VEGETATION, AND DISTURBANCE TO THE SOIL, IS TO BE KEPT TO AN ABSOLUTE MINIMUM WHILE ALLOWING PROPER DEVELOPMENT OF THE SITE.

EROSION AND SEDIMENT CONTROL MAINTENANCE PROCEDURES


DURING CONSTRUCTION, AS SMALL AN AREA OF SOIL AS POSSIBLE SHOULD BE EXPOSED OR AS SHORT A TIME AS POSSIBLE. AFTER CONSTRUCTION, GRADE, RESPREAD TOPSOIL, AND STABILIZE SOIL BY SEEDING AND MULCHING AS TO PREVENT EROSION.

ALL SEDIMENTATION AND EROSION CONTROL DEVICES SHALL BE INSPECTED DURING CONSTRUCTION ON A DAILY BASIS AND FOLLOWING ALL STORMS BY THE RESIDENT ENGINEER. THE CONTRACTOR SHALL MAINTAIN AND MAKE REPAIRS AND REMOVE SEDIMENT AS REQUESTED BY THE RESIDENT ENGINEER. THIS WORK SHALL BE PERFORMED WITHIN 24 HOURS OF REQUEST.

THE CONTRACTOR SHALL CLEAN SEDIMENT AND DEBRIS FROM ALL DRAINAGE STRUCTURES, AND PIPES AT THE COMPLETION OF CONSTRUCTION, THE CONTRACTOR SHALL REPAIR ALL ERODED AREAS AND ENSURE A GOOD STAND OF TURF IS ESTABLISHED THROUGHOUT. THE CONTRACTOR SHALL REPAIR ALL ERODED OR DISPLACED RIPRAP, AND CLEAN SEDIMENT COVERED STONES.


CONSTRUCTION PROCEDURES:

- HAY BALES SHALL BE PLACED AROUND EXISTING CATCH BASINS AND DROP INLETS TO PREVENT SEDIMENTATION AND OTHER DEBRIS FROM ACCUMULATING ON THE GRATE OR IN THE SUMP. HAY BALES SHOULD BE KEPT CLEAN AND FREE OF DEBRIS TO FACILITATE FLOW.
- EACH BALE SHALL BE EMBEDDED IN THE SOIL A MINIMUM OF 4 INCHES, AND PLACED SO THE BINDINGS ARE HORIZONTAL.
- BALES SHALL BE SECURELY ANCHORED IN PLACE BY EITHER TWO STAKES OR REBARS DRIVEN THROUGH THE BALE. THE FIRST STAKE SHALL BE DRIVEN TOWARD THE PREVIOUSLY LAID BALE AT AN ANGLE TO FORCE THE BALES TOGETHER. STAKES SHALL BE DRIVEN FLUSH WITH THE BALE.
- INSPECTION SHALL BE FREQUENT AND REPAIR REPLACEMENT SHALL BE MADE PROMPTLY AS NEEDED.
- BALES SHALL BE REMOVED WHEN THEY HAVE SERVED THEIR USEFULNESS SO AS NOT TO BLOCK OR IMPEDE STORM FLOW OR DRAINAGE.

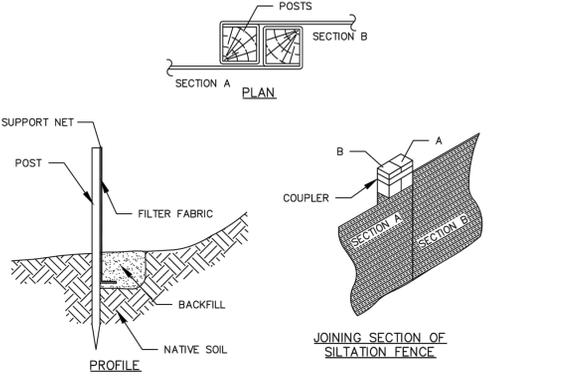

CONSTRUCTION NOTES

- WOVEN WIRE FENCE TO BE FASTENED SECURELY TO FENCE POST WITH WIRE TIES OR STAPLES.
- FILTER FABRIC TO BE FASTENED SECURELY TO WOVEN WIRE FENCE WITH TIES SPACED EVERY 24" AT TOP AND MID SECTION.
- WHEN TWO SECTIONS OF FILTER FABRIC ADJOIN EACH OTHER, THEY SHALL BE OVERLAPPED BY 6 INCHES AND FOLDED.
- MAINTENANCE SHALL BE PERFORMED AS NEEDED AND MATERIAL REMOVED WHEN "BULGES" DEVELOP IN THE SILT FENCE.
- INSPECTION SHALL BE FREQUENT AND REPAIR REPLACEMENT SHALL BE MADE PROMPTLY AS NEEDED.
- FENCES SHALL BE REMOVED WHEN THEY HAVE SERVED THEIR USEFULNESS SO AS NOT TO BLOCK OR IMPEDE STORM FLOW OR DRAINAGE.

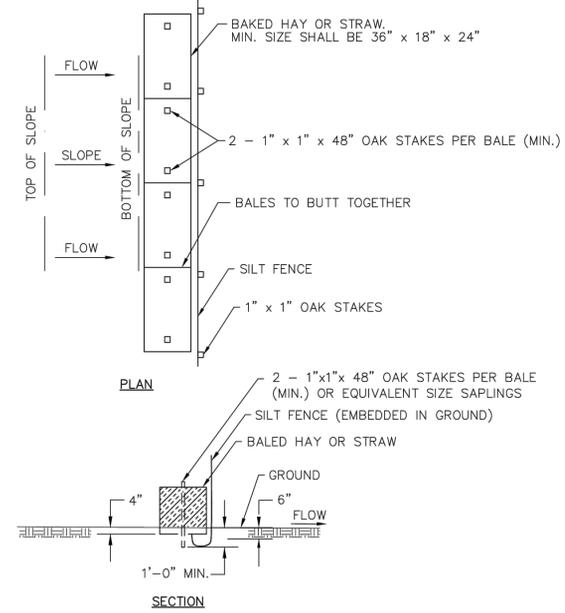

TOWN OF CONCORD—PUBLIC WORKS DESIGN AND CONSTRUCTION STANDARDS		
EROSION AND SEDIMENTATION CONTROL NOTES		
SCALE: N.T.S.	DATE: 01/08/2015	
JOB NO./FILE NAME:	DESIGNED BY: JCZ	PLAN NO.
FILE.DWG	DRAWN BY: JCZ	EC-1
	CHECKED BY: W.J.R.	





TOWN OF CONCORD—PUBLIC WORKS DESIGN AND CONSTRUCTION STANDARDS		
EROSION AND SEDIMENTATION CONTROL NOTES (CONTINUED)		
SCALE: N.T.S.	DATE: 01/08/2015	
JOB NO./FILE NAME:	DESIGNED BY: JCZ	PLAN NO.
FILE.DWG	DRAWN BY: JCZ	EC-2
	CHECKED BY: W.J.R.	





TOWN OF CONCORD—PUBLIC WORKS DESIGN AND CONSTRUCTION STANDARDS		
SILTATION FENCE		
SCALE: N.T.S.	DATE: 01/08/2015	
JOB NO./FILE NAME:	DESIGNED BY: JCZ	PLAN NO.
FILE.DWG	DRAWN BY: JCZ	EC-3
	CHECKED BY: W.J.R.	





TOWN OF CONCORD—PUBLIC WORKS DESIGN AND CONSTRUCTION STANDARDS		
HAYBALES AND SILT FENCE		
SCALE: N.T.S.	DATE: 01/08/2015	
JOB NO./FILE NAME:	DESIGNED BY: JCZ	PLAN NO.
FILE.DWG	DRAWN BY: JCZ	EC-4
	CHECKED BY: W.J.R.	

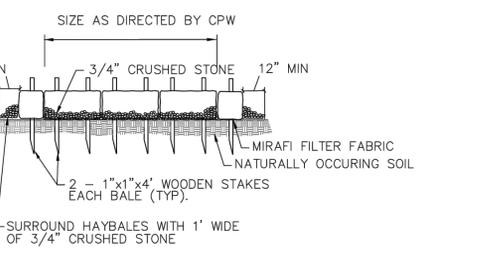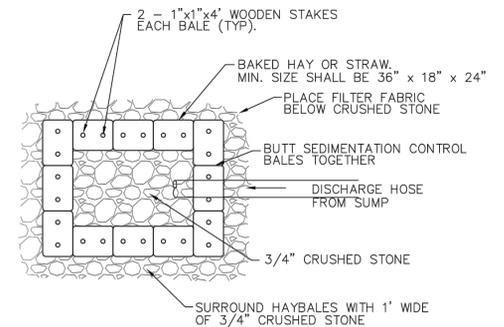



TOWN OF CONCORD—PUBLIC WORKS DESIGN AND CONSTRUCTION STANDARDS		
ONSITE DEWATERING BASIN		
SCALE: N.T.S.	DATE: 01/08/2015	
JOB NO./FILE NAME:	DESIGNED BY: JCZ	PLAN NO.
FILE.DWG	DRAWN BY: JCZ	EC-5
	CHECKED BY: W.J.R.	

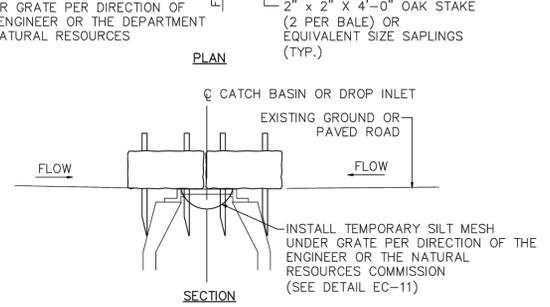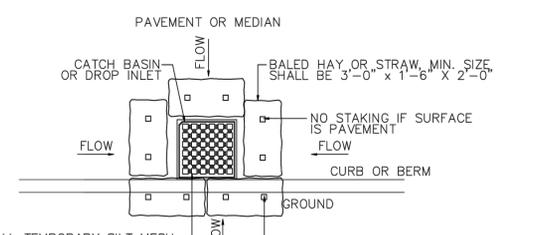


TOWN OF CONCORD—PUBLIC WORKS DESIGN AND CONSTRUCTION STANDARDS		
DRAIN INLET PROTECTION		
SCALE: N.T.S.	DATE: 01/08/2015	
JOB NO./FILE NAME:	DESIGNED BY: JCZ	PLAN NO.
FILE.DWG	DRAWN BY: JCZ	EC-6
	CHECKED BY: W.J.R.	

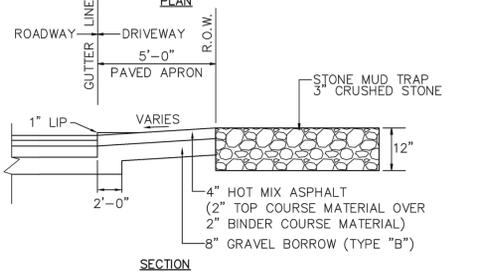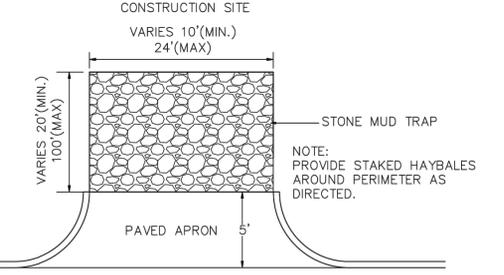


TOWN OF CONCORD—PUBLIC WORKS DESIGN AND CONSTRUCTION STANDARDS		
TEMPORARY CONSTRUCTION ENTRANCE		
SCALE: N.T.S.	DATE: 01/08/2015	
JOB NO./FILE NAME:	DESIGNED BY: JCZ	PLAN NO.
FILE.DWG	DRAWN BY: JCZ	EC-7
	CHECKED BY: W.J.R.	

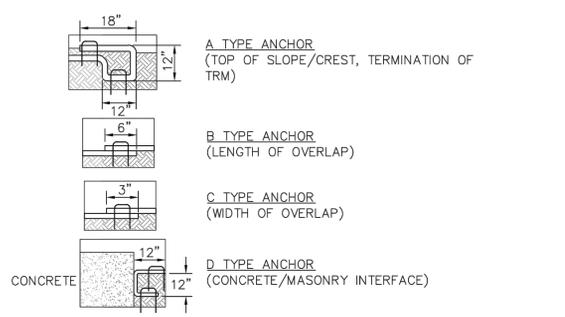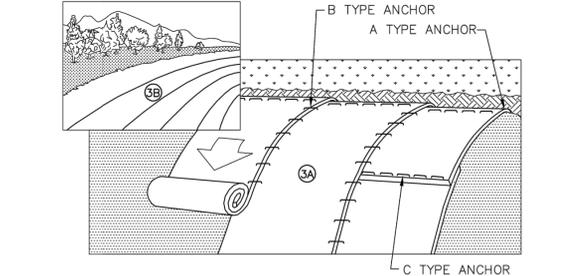

TOWN OF CONCORD—PUBLIC WORKS DESIGN AND CONSTRUCTION STANDARDS		
EROSION CONTROL MATTING		
SCALE: N.T.S.	DATE: 01/08/2015	
JOB NO./FILE NAME:	DESIGNED BY: JCZ	PLAN NO.
FILE.DWG	DRAWN BY: JCZ	EC-8
	CHECKED BY: W.J.R.	

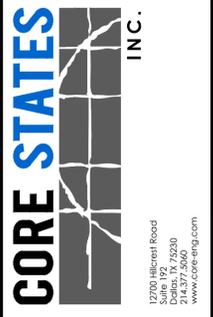

DOCUMENTS PREPARED BY CORE STATES, INC. INCLUDING THIS DOCUMENT ARE TO BE USED ONLY FOR THE SPECIFIC PROJECT AND SPECIFIC USE FOR WHICH THEY WERE INTENDED. ANY EXTENSION OF USE TO ANY OTHER PROJECTS, BY OWNER OR BY ANY OTHER PARTY, WITHOUT THE EXPRESSED WRITTEN CONSENT OF CORE STATES, INC. IS DONE UNLAWFULLY AND AT THE USER'S OWN RISK. IT IS USED IN ANY OTHER MANNER THAN THAT SPECIFICALLY INTENDED, USER WILL HOLD CORE STATES, INC. HARMLESS FROM ALL CLAIMS AND LOSSES.

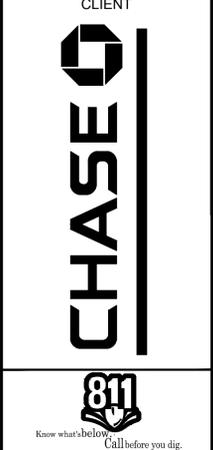

THE CONTRACTOR SPECIFICALLY WARRANTS THAT THE LOCATION AND DEPTH OF EXISTING UTILITIES SHOWN ON THESE PLANS OR DESIGN INFORMATION IS CORRECT. CORE STATES, INC. DOES NOT WARRANT THE LOCATION AND DEPTH OF UTILITIES SHOWN ON THESE PLANS OR DESIGN INFORMATION. THE CONTRACTOR SHALL VERIFY THE LOCATION AND DEPTH OF UTILITIES PRIOR TO CONSTRUCTION.

REV	DATE	COMMENT	BY
1	06/01/20	REVISED PER TOWNSHIP COMMENTS	KGF

DOCUMENT SITE PLAN APPROVAL FOR CHASE BANK

SITE LOCATION MAIN STREET & BAKER AVENUE 1134 MAIN STREET CONCORD, MA 01742

ENGINEER SEAL

ALAN D. ROSCOE, P.E. MA LICENSE #40163 SHEET TITLE EROSION CONTROL DETAILS

JOB #:	JPM-27599
DATE:	04/28/2020
SCALE:	AS SHOWN
DRAWN BY:	CC
CHECKED BY:	TP

SHEET NO. CD-2

EROSION CONTROL MATTING INSTALLATION NOTES


- INSTALL TURF REINFORCEMENT MAT (TRM) IN ACCORDANCE WITH MANUFACTURERS INSTRUCTIONS. MANUFACTURERS REPRESENTATIVE SHALL INSPECT THE SITE PREPARATION PRIOR TO INSTALLATION OF THE TURF REINFORCEMENT MAT AND PROVIDE ON SITE SUPERVISION FOR THE INSTALLATION. UPON COMPLETION, THE REPRESENTATIVE SHALL PROVIDE WRITTEN CERTIFICATION AS TO THE ACCEPTABILITY OF THE INSTALLATION.
 - PREPARE SOIL BEFORE INSTALLING TRM, INCLUDING ANY NECESSARY APPLICATION OF LIME, FERTILIZER AND SEED. NOTE: WHEN USING CELL DO NOT SEED PREPARED AREA. CELL-0-SEED MUST BE INSTALLED WITH PAPER SIDE DOWN.
 - BEGIN AT THE TOP OF THE SLOPE BY ANCHORING THE TRM IN A 6"x6" TRENCH WITH APPROXIMATELY 12" OF TRM EXTENDED BEYOND THE UP-SLOPE PORTION OF THE TRENCH. ANCHOR THE TRM WITH A ROW OF STAPLES/STAKES APPROXIMATELY 12" APART IN THE BOTTOM OF THE TRENCH. BACKFILL AND COMPACT THE TRENCH AFTER STAPLING. APPLY SEED TO COMPACTED SOIL AND FOLD REMAINING 12" PORTION OF TRM BACK OVER SEED AND COMPACTED SOIL. SECURE TRM OVER COMPACTED SOIL WITH A ROW OF STAPLES/STAKES SPACED APPROXIMATELY 12" APART ACROSS THE WIDTH OF THE TRM.
 - ROLL THE TRM (A) DOWN OR (B) HORIZONTALLY ACROSS THE SLOPE. TRM WILL UNROLL WITH APPROPRIATE SIDE AGAINST THE SOIL SURFACE. ALL TRM MUST BE SECURELY FASTENED TO SOIL SURFACE BY PLACING STAPLES/STAKES IN APPROPRIATE LOCATIONS AS SHOWN IN THE STAPLE PATTERN GUIDE. WHEN USING THE DOT SYSTEM, STAPLES/STAKES SHOULD BE PLACED THROUGH EACH OF THE COLORED DOTS CORRESPONDING TO THE APPROPRIATE STAPLE PATTERN.
 - THE EDGES OF PARALLEL TRM MUST BE STAPLED WITH APPROXIMATELY 2"-5" OVERLAP DEPENDING ON TRM TYPE.
 - CONSECUTIVE TRM SPICED DOWN THE SLOPE MUST BE PLACED END OVER END (SHINGLE STYLE) WITH AN APPROXIMATE 6" OVERLAP. STAPLE THROUGH OVERLAPPED AREA, APPROXIMATELY 12" APART ACROSS ENTIRE TRM WIDTH.
- NOTE: IN LOOSE SOIL CONDITIONS, THE USE OF STAPLE OR STAKE LENGTHS GREATER THAN 6" MAY BE NECESSARY TO PROPERLY SECURE THE TRM.
- WHERE THE BLANKETS RUN PARALLEL TO CONCRETE OR STONE MASONRY WALL, PLACE AND SECURE BLANKET WITH D-TYPE ANCHOR.



TOWN OF CONCORD—PUBLIC WORKS
DESIGN AND CONSTRUCTION
STANDARDS

EROSION CONTROL MATTING INSTALLATION
NOTES


SCALE: N.T.S.	DATE: 01/08/2015
JOB NO./FILE NAME:	DESIGNED BY: JCZ
FILE.DWG	DRAWN BY: JCZ
	CHECKED BY: W.J.R.
PLAN NO.	EC-9

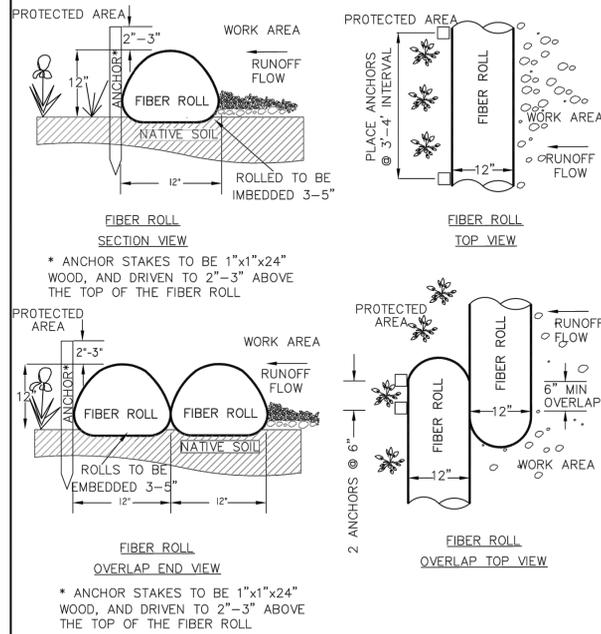

TOWN OF CONCORD—PUBLIC WORKS
DESIGN AND CONSTRUCTION
STANDARDS

EROSION CONTROL FIBER ROLL DETAIL


SCALE: N.T.S.	DATE: 01/08/2015
JOB NO./FILE NAME:	DESIGNED BY: JCZ
FILE.DWG	DRAWN BY: JCZ
	CHECKED BY: W.J.R.
PLAN NO.	EC-10

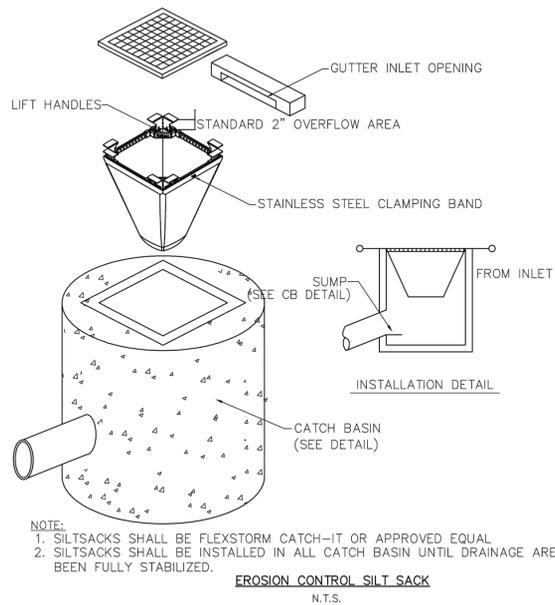

TOWN OF CONCORD—PUBLIC WORKS
DESIGN AND CONSTRUCTION
STANDARDS

EROSION CONTROL SILT SACK DETAIL


SCALE: N.T.S.	DATE: 08/10/2017
JOB NO./FILE NAME:	DESIGNED BY: JCZ
FILE.DWG	DRAWN BY: JCZ
	CHECKED BY: W.J.R.
PLAN NO.	EC-11

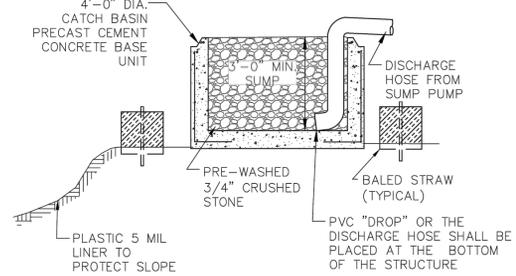

TOWN OF CONCORD—PUBLIC WORKS
DESIGN AND CONSTRUCTION
STANDARDS

DEWATERING SUMP DETAIL

SCALE: N.T.S.	DATE: 01/08/2015
JOB NO./FILE NAME:	DESIGNED BY: JCZ
FILE.DWG	DRAWN BY: JCZ
	CHECKED BY: W.J.R.
PLAN NO.	EC-12

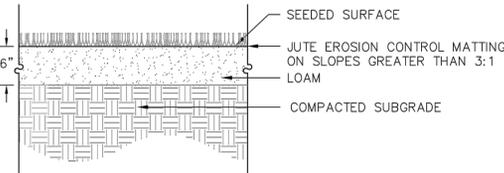

TOWN OF CONCORD—PUBLIC WORKS
DESIGN AND CONSTRUCTION
STANDARDS

LOAM AND SEED DETAIL

SCALE: N.T.S.	DATE: 01/08/2015
JOB NO./FILE NAME:	DESIGNED BY: JCZ
FILE.DWG	DRAWN BY: JCZ
	CHECKED BY: W.J.R.
PLAN NO.	EC-13



DOCUMENTS PREPARED BY CORE STATES, INC. INCLUDING THIS DOCUMENT ARE TO BE USED ONLY FOR THE SPECIFIC PROJECT AND SPECIFIC USE FOR WHICH THEY WERE INTENDED. ANY EXTENSION OF USE TO ANY OTHER PROJECTS, BY OWNER OR BY ANY OTHER PARTY, WITHOUT THE EXPRESSED WRITTEN CONSENT OF CORE STATES, INC. IS UNLAWFUL AND AT THE USER'S OWN RISK. IT IS USED IN A WAY OTHER THAN THAT SPECIFICALLY INTENDED. USER WILL HOLD CORE STATES, INC. HARMLESS FROM ALL CLAIMS AND LOSSES.

CLIENT



Know what's below. Call before you dig.

The CONTRACTOR is specifically cautioned that the location and/or location of existing utilities as shown on these drawings is based on records and field verification. CORE STATES, INC. DOES NOT GUARANTEE THE LOCATION OR DEPTH OF ANY UTILITIES SHOWN ON THESE DRAWINGS. THE CONTRACTOR SHALL VERIFY THE LOCATION AND DEPTH OF ALL UTILITIES PRIOR TO ANY EXCAVATION OR CONSTRUCTION. THE CONTRACTOR SHALL BE RESPONSIBLE FOR ANY DAMAGE TO UTILITIES.

REV	DATE	COMMENT	BY
1	08/01/20	REVISED PER TOWNSHIP COMMENTS	KGF

DOCUMENT SITE PLAN APPROVAL FOR CHASE BANK

SITE LOCATION
MAIN STREET &
BAKER AVENUE
1134 MAIN STREET
CONCORD, MA 01742


ENGINEER SEAL

ALAN D. ROSCOE, P.E.
MA LICENSE #40163
SHEET TITLE
EROSION CONTROL
DETAILS

JOB #:	JPM-27599
DATE:	04/28/2020
SCALE:	AS SHOWN
DRAWN BY:	CC
CHECKED BY:	TP

SHEET NO.
CD-3

ASPHALT TYPE	LAYER DEPTH STANDARD DUTY
ASPHALTIC CONCRETE SURFACE COURSE	1.5"
BITUMINOUS CONCRETE BINDER COURSE	1.5"
DENSE-GRADED CRUSHED STONE SUBBASE	6"
PROCESSED GRAVEL SUBBASE	12"

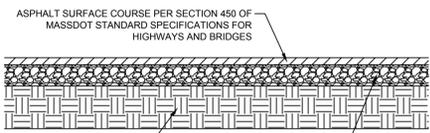

ASPHALT SURFACE COURSE PER SECTION 450 OF MASSDOT STANDARD SPECIFICATIONS FOR HIGHWAYS AND BRIDGES


AGGREGATE BASE COURSE PER SECTION 430 OF MASSDOT STANDARD SPECIFICATIONS FOR HIGHWAYS & BRIDGES

- NOTES:
- AGGREGATE BASE COURSE CAN BE LIMEROCK OR CRUSHED CONCRETE (LBR = 100) COMPACT BASE COURSE TO 98% OF THE MATERIALS MAXIMUM DRY DENSITY PER ASTM D-1557.
 - COMPACTED SUBGRADE TO ACHIEVE A MINIMUM LBR OF 40.

N.T.S.

ASPHALT PAVING DETAIL

SLAB COMPONENT	CONCRETE SLAB LOCATION	
	INTERIOR	OUTER 2'
CONCRETE PAVEMENT	6"	12"
COMPACTED SUBGRADE	12"	12"
MINIMUM 28 DAY STRENGTH	4000 PSI	4000 PSI

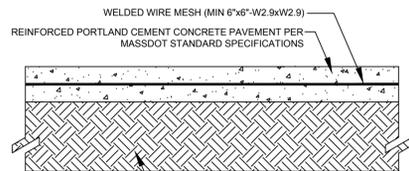


NOTE: THESE SPECIFICATIONS ARE BASED ON GEOTECHNICAL REPORT. REFER TO REPORT FOR FINAL SPECIFICATIONS.

NOTES:

- SUBGRADE MATERIALS SHALL MEET MASSDOT REQUIREMENTS INCLUDING COMPACTION TO 98% OF ITS MAXIMUM DRY DENSITY AS DETERMINED BY ASTM D-1557.
- CONCRETE PAVEMENT SHALL MEET THE MORE STRINGENT REQUIREMENT OF EITHER THE SPECIFICATIONS PROVIDED BY THE OWNER, LOCAL CITY/COUNTY REQUIREMENTS, OR MASSDOT STANDARD SPECIFICATIONS FOR ROAD AND BRIDGE CONSTRUCTION.
- CONTRACTOR TO CONSTRUCT CONCRETE PAVEMENT WITH TRANSVERSE JOINTS AT 10' O.C. JOINTS TO BE CONSTRUCTED PER DETAIL ON THIS PAGE.
- CONTRACTOR TO DOWEL AND JOINT BETWEEN CONCRETE SLAB AND CURB.


N.T.S.

CONCRETE PAVEMENT DETAIL

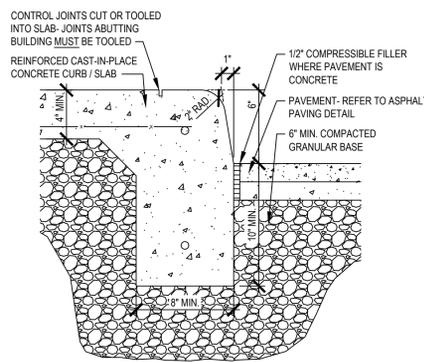


N.T.S.

PEDESTRIAN WALK CURB

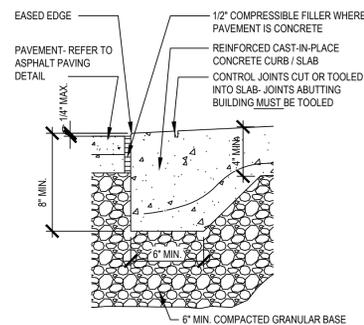


N.T.S.

FLUSH CURB

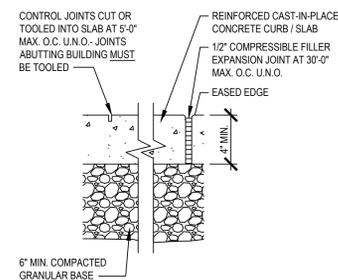


N.T.S.

PEDESTRIAN WALK EXPANSION JOINT

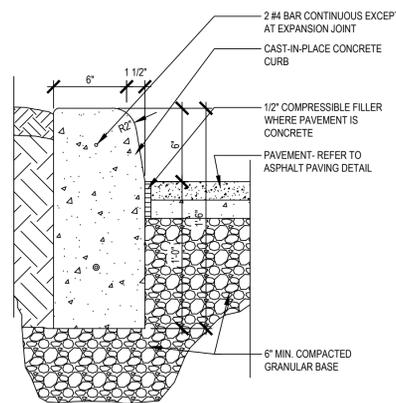


N.T.S.

BARRIER CURB

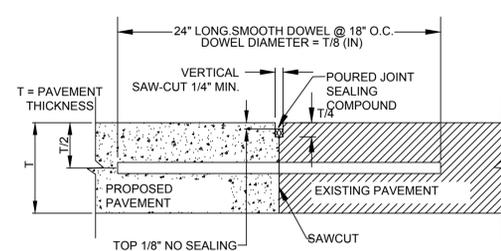


- NOTE:
- DOWEL BARS SHALL BE DRILLED INTO PAVEMENT HORIZONTALLY BY USE OF A MECHANICAL RIG.
 - DRILLING BY HAND IS NOT ACCEPTABLE. PUSHING DOWEL BARS INTO GREEN CONCRETE IS NOT ACCEPTABLE.

BUTT JOINT

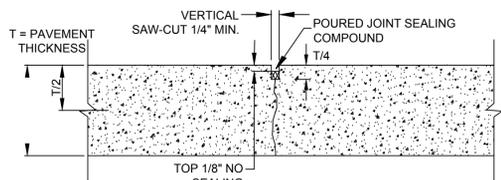


CONTRACTION JOINT

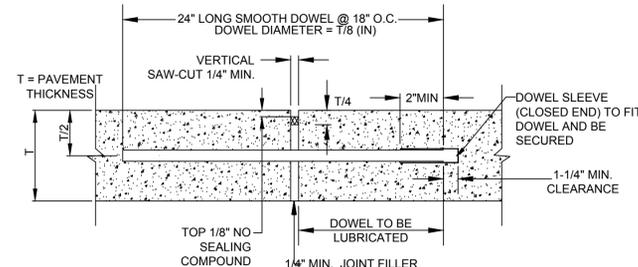

- NOTE:
- DOWELS SHALL BE SUPPORTED BY AN APPROVED DEVICE.

TRANSVERSE EXPANSION JOINT

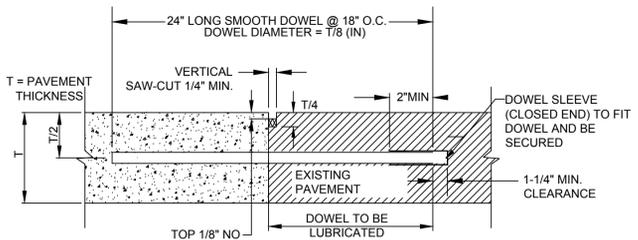

- NOTE:
- DOWELS SHALL BE SUPPORTED BY AN APPROVED DEVICE.


CONSTRUCTION JOINT

N.T.S.

CONCRETE JOINT DETAILS

	DRIVE THRU & ADA PARKING PAD	TRASH ENCLOSURE
CONCRETE MAT	LAYER DEPTH 6"	LAYER DEPTH 8"
DENSE GRADE AGGREGATE SUBBASE	6"	6"
MINIMUM 28 DAY STRENGTH	4,500 PSI	4,500 PSI

6 X 6 X 6 CO. W.W.M.
REINFORCED PORTLAND CEMENT CONCRETE PAVEMENT
DENSE GRADE AGGREGATE SUBBASE

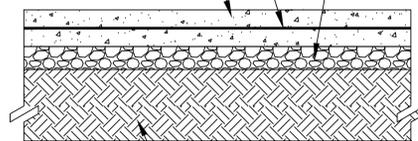


DETAIL NOTES:

- CONCRETE PAVEMENT SHALL MEET THE MORE STRINGENT REQUIREMENT OF EITHER THE SPECIFICATIONS PROVIDED BY THE OWNER, LOCAL CITY/COUNTY REQUIREMENTS.
- CONTRACTOR TO CONSTRUCT CONCRETE PAVEMENT WITH TRANSVERSE JOINTS AT 10' O.C. JOINTS TO BE CONSTRUCTED PER DETAIL ON THIS PAGE.

N.T.S.


CONCRETE SLAB SECTION

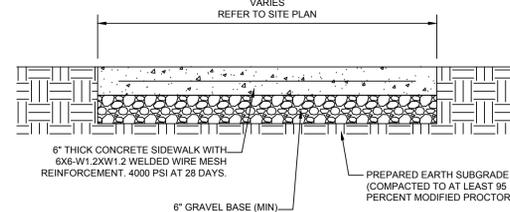

NOTES:

- PROVIDE 1/2" PREMOLDED EXPANSION JOINT FILLER AT 60' CENTERS, CHANGES IN DIRECTION, AND ABUTTING SEPARATE POURS.
- PROVIDE TOOLED CONTRACTION JOINTS AT 10' CENTERS.
- CONTRACTOR TO PREPARE SUBGRADE BASED ON RECOMMENDATIONS IN THE GEOTECHNICAL INVESTIGATION REPORT.

CONCRETE SIDEWALK DETAIL

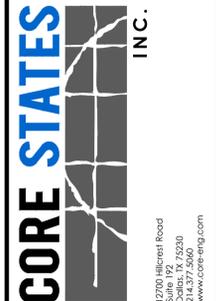

DOCUMENTS PREPARED BY CORE STATES, INC. INCLUDING THIS DOCUMENT ARE TO BE USED ONLY FOR THE SPECIFIC PROJECT AND SPECIFIC USE FOR WHICH THEY WERE INTENDED. ANY EXTENSION OF USE TO ANY OTHER PROJECTS, BY OWNER OR BY ANY OTHER PARTY, WITHOUT THE EXPRESSED WRITTEN CONSENT OF CORE STATES, INC. IS DONE UNLAWFULLY AND AT THE USER'S OWN RISK. IT IS USED IN A WAY OTHER THAN THAT SPECIFICALLY INTENDED. USER WILL HOLD CORE STATES, INC. HARMLESS FROM ALL CLAIMS AND LOSSES.

CLIENT



Know what's below. Call before you dig. The contractor is specifically cautioned that the location and/or elevation of existing utilities as shown on these drawings are based on measurements taken in the field. CORE STATES, INC. DOES NOT GUARANTEE THE LOCATION, DEPTH OR DATE OF THE UTILITIES SHOWN ON THESE DRAWINGS. THE USER SHALL VERIFY THE LOCATION AND DEPTH OF UTILITIES PRIOR TO ANY EXCAVATION WORK.

REV	DATE	COMMENT	BY
1	06/01/20	REVISED PER TOWNSHIP COMMENTS	KGF

DOCUMENT SITE PLAN APPROVAL FOR CHASE BANK

SITE LOCATION
MAIN STREET & BAKER AVENUE
1134 MAIN STREET
CONCORD, MA 01742




ENGINEER SEAL

ALAN D. ROSCOE, P.E.
MA LICENSE #40163
SHEET TITLE
CONSTRUCTION DETAILS

JOB #:	JPM-27599
DATE:	04/28/2020
SCALE:	AS SHOWN
DRAWN BY:	CC
CHECKED BY:	TP

SHEET NO.

CD-4

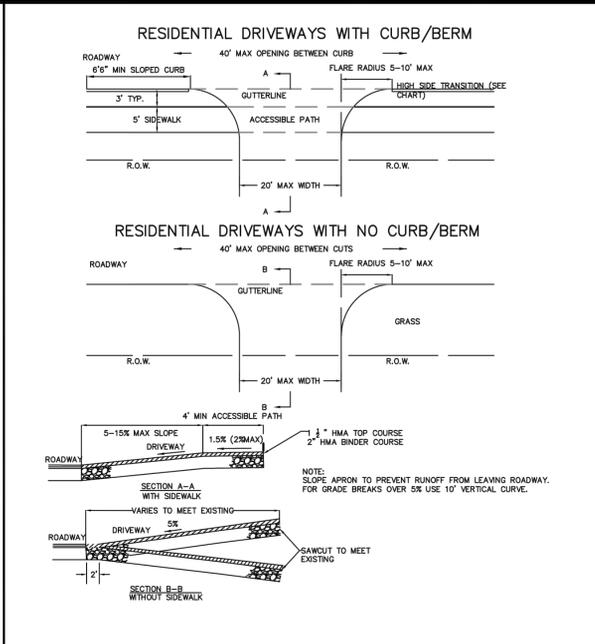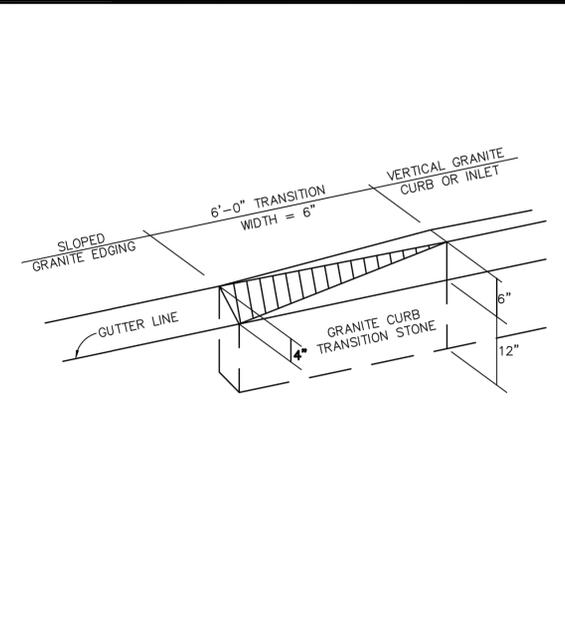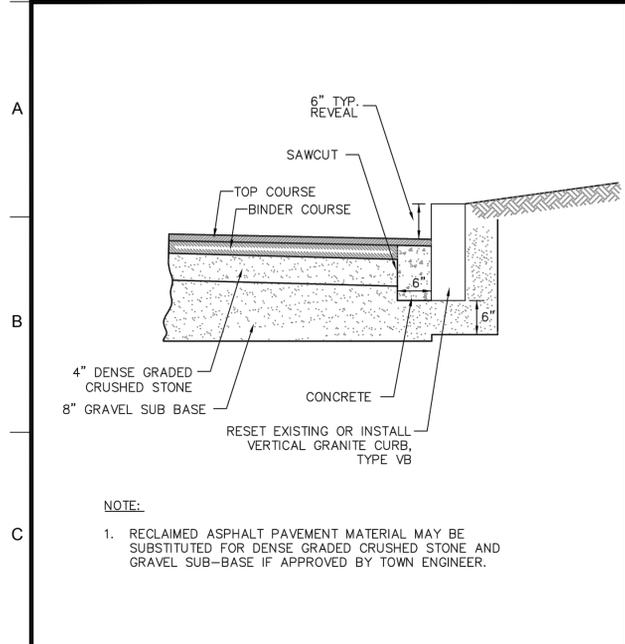

TOWN OF CONCORD—PUBLIC WORKS DESIGN AND CONSTRUCTION STANDARDS

VERTICAL GRANITE CURB

SCALE: N.T.S. DATE: 01/08/2015

JOB NO./FILE NAME:	DESIGNED BY: JCZ	PLAN NO.
FILE.DWG	DRAWN BY: JCZ	RS-3
	CHECKED BY: W.J.R.	

TOWN OF CONCORD—PUBLIC WORKS DESIGN AND CONSTRUCTION STANDARDS

EDGING TO CURB TRANSITION

SCALE: N.T.S. DATE: 01/08/2015




JOB NO./FILE NAME:	DESIGNED BY: JCZ	PLAN NO.
FILE.DWG	DRAWN BY: JCZ	RS-5
	CHECKED BY: W.J.R.	

TOWN OF CONCORD—PUBLIC WORKS DESIGN AND CONSTRUCTION STANDARDS

TYPICAL DRIVEWAY DETAIL

SCALE: N.T.S. DATE: 03/05/2014

JOB NO./FILE NAME:	DESIGNED BY: JCZ	PLAN NO.
FILE.DWG	DRAWN BY: JCZ	RS-17
	CHECKED BY: W.J.R.	

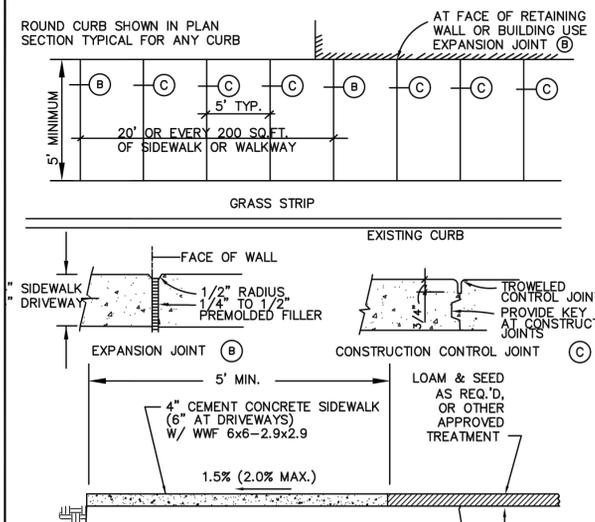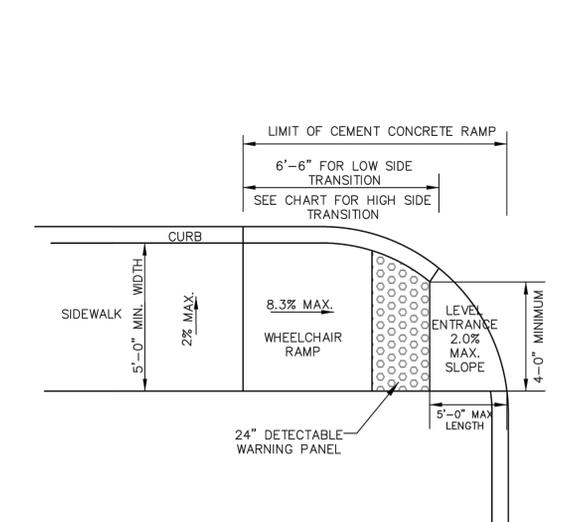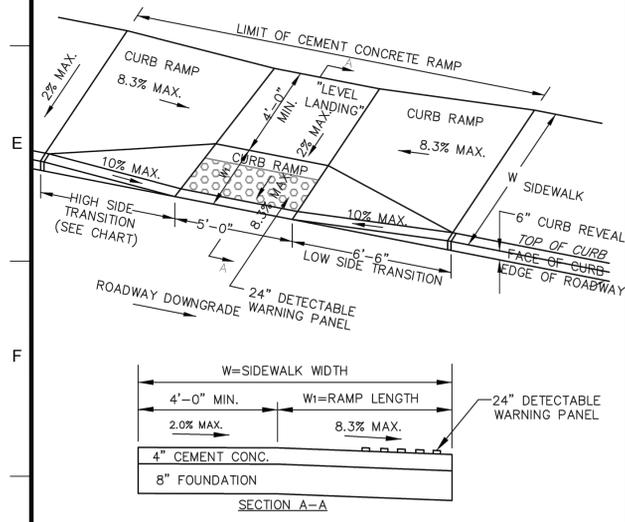

TOWN OF CONCORD—PUBLIC WORKS DESIGN AND CONSTRUCTION STANDARDS

CURB RAMP TYPE A (COMBINATION RAMP)

SCALE: N.T.S. DATE: 01/08/2016

JOB NO./FILE NAME:	DESIGNED BY: JCZ	PLAN NO.
FILE.DWG	DRAWN BY: JCZ	RS-10
	CHECKED BY: W.J.R.	

TOWN OF CONCORD—PUBLIC WORKS DESIGN AND CONSTRUCTION STANDARDS

CURB RAMP TYPE B (SINGLE DIRECTION RAMP)

SCALE: N.T.S. DATE: 01/08/2015


JOB NO./FILE NAME:	DESIGNED BY: JCZ	PLAN NO.
FILE.DWG	DRAWN BY: JCZ	RS-11
	CHECKED BY: W.J.R.	

TOWN OF CONCORD—PUBLIC WORKS DESIGN AND CONSTRUCTION STANDARDS

CEMENT CONCRETE SIDEWALK

SCALE: N.T.S. DATE: 01/08/2015

JOB NO./FILE NAME:	DESIGNED BY: JCZ	PLAN NO.
FILE.DWG	DRAWN BY: JCZ	RS-8
	CHECKED BY: W.J.R.	

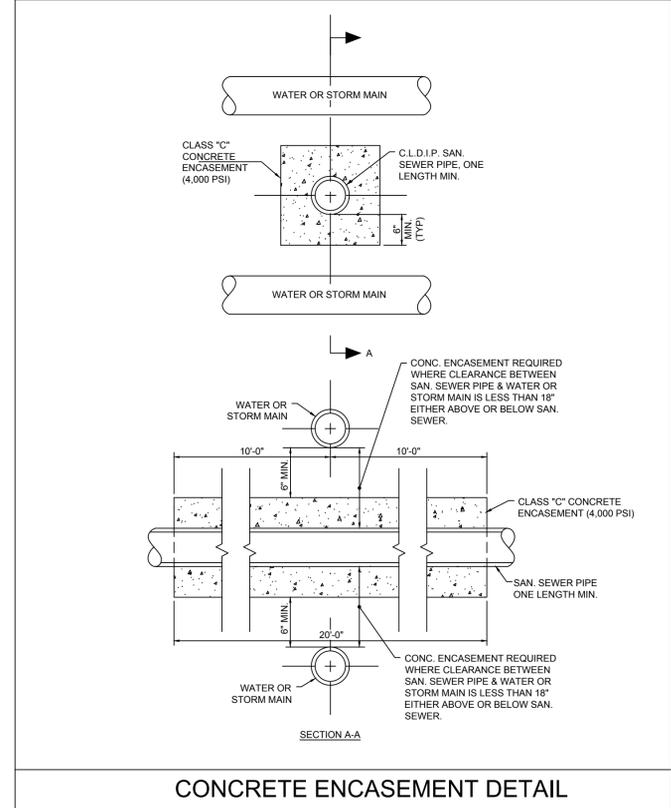

TOWN OF CONCORD—PUBLIC WORKS DESIGN AND CONSTRUCTION STANDARDS

CURB RAMP TYPE A (COMBINATION RAMP)

SCALE: N.T.S. DATE: 01/08/2016

JOB NO./FILE NAME:	DESIGNED BY: JCZ	PLAN NO.
FILE.DWG	DRAWN BY: JCZ	RS-10
	CHECKED BY: W.J.R.	

TOWN OF CONCORD—PUBLIC WORKS DESIGN AND CONSTRUCTION STANDARDS

CURB RAMP TYPE B (SINGLE DIRECTION RAMP)

SCALE: N.T.S. DATE: 01/08/2015

JOB NO./FILE NAME:	DESIGNED BY: JCZ	PLAN NO.
FILE.DWG	DRAWN BY: JCZ	RS-11
	CHECKED BY: W.J.R.	

TOWN OF CONCORD—PUBLIC WORKS DESIGN AND CONSTRUCTION STANDARDS

CEMENT CONCRETE SIDEWALK

SCALE: N.T.S. DATE: 01/08/2015

JOB NO./FILE NAME:	DESIGNED BY: JCZ	PLAN NO.
FILE.DWG	DRAWN BY: JCZ	RS-8
	CHECKED BY: W.J.R.	

CORE STATES INC.

1270 Haverhill Road
Dorset, MA 01920
314.377.5660
www.corestates.com

DOCUMENTS PREPARED BY CORE STATES, INC. INCLUDING THIS DOCUMENT ARE TO BE USED ONLY FOR THE SPECIFIC PROJECT AND SPECIFIC USE FOR WHICH THEY WERE INTENDED. ANY EXTENSION OF USE TO ANY OTHER PROJECTS, BY OWNER OR BY ANY OTHER PARTY, WITHOUT THE EXPRESSED WRITTEN CONSENT OF CORE STATES, INC. IS DONE UNLAWFULLY AND AT THE USER'S OWN RISK. IT IS USED IN A WAY OTHER THAN THAT SPECIFICALLY INTENDED. USER WILL HOLD CORE STATES, INC. HARMLESS FROM ALL CLAIMS AND LOSSES.

CLIENT

CHASE

811

Know what's below. Call before you dig.

REV	DATE	COMMENT	BY
1	06/01/20	REVISED PER TOWNSHIP COMMENTS	KGF

DOCUMENT SITE PLAN APPROVAL FOR CHASE BANK


SITE LOCATION
MAIN STREET & BAKER AVENUE
1134 MAIN STREET
CONCORD, MA 01742

ENGINEER SEAL


ALAN D. ROSCOE, P.E.
MA LICENSE #40163
SHEET TITLE
CONSTRUCTION DETAILS

JOB #:	JPM-27599
DATE:	04/28/2020
SCALE:	AS SHOWN
DRAWN BY:	CC
CHECKED BY:	TP


SHEET NO.
CD-6

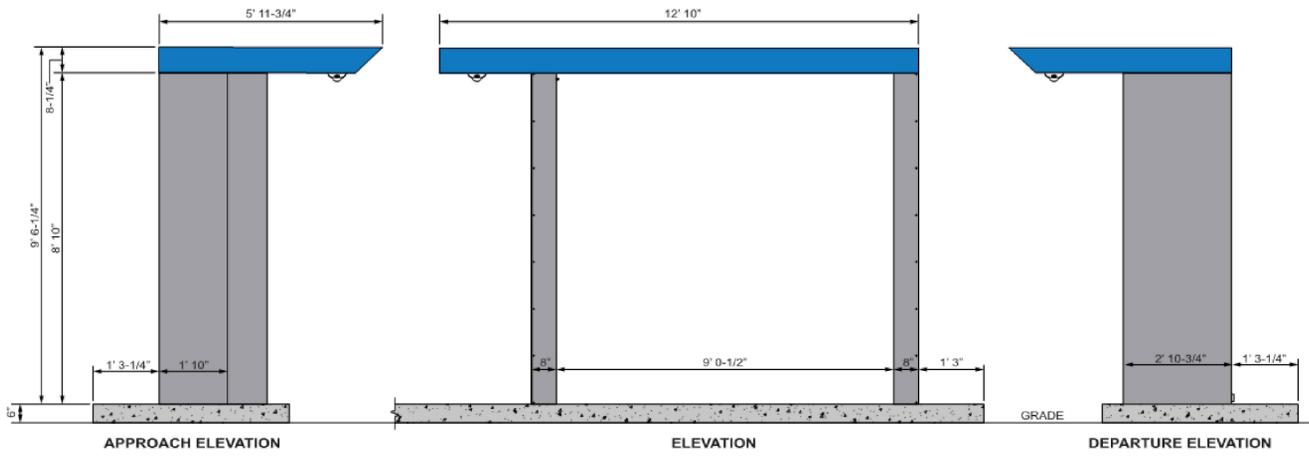


CHASE SIGNATURE ATM DRIVE-UP CANOPY - NO BRANDING
N.T.S.

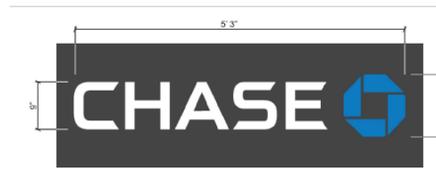


CHASE CUSTOM TRANSOM SIGN
N.T.S.

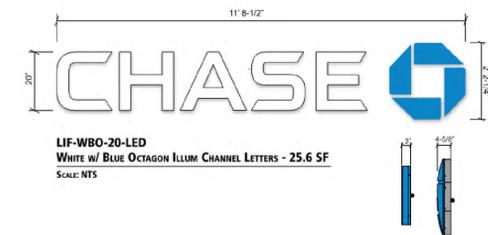

CHASE ILLUM CHANNEL LETTERS SIGN
N.T.S.

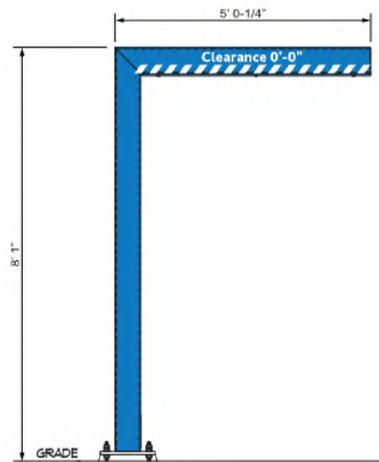



CHASE CLEARANCE BAR
N.T.S.

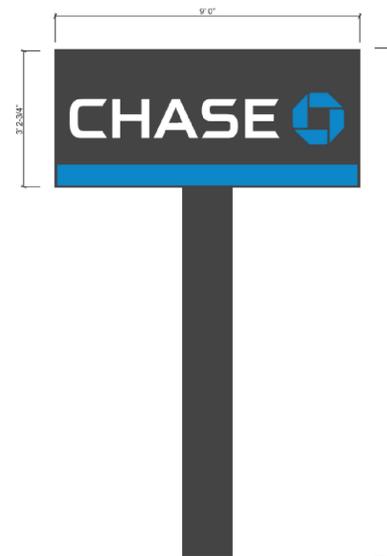

CHASE DOUBLE-FACED ILLUMINATED PYLON SIGN
N.T.S.



CHASE SINGLE-FACED NON-ILLUMINATED DIRECTIONAL SIGN
N.T.S.

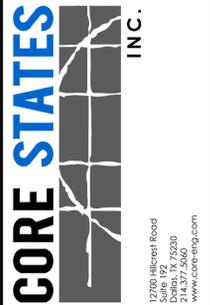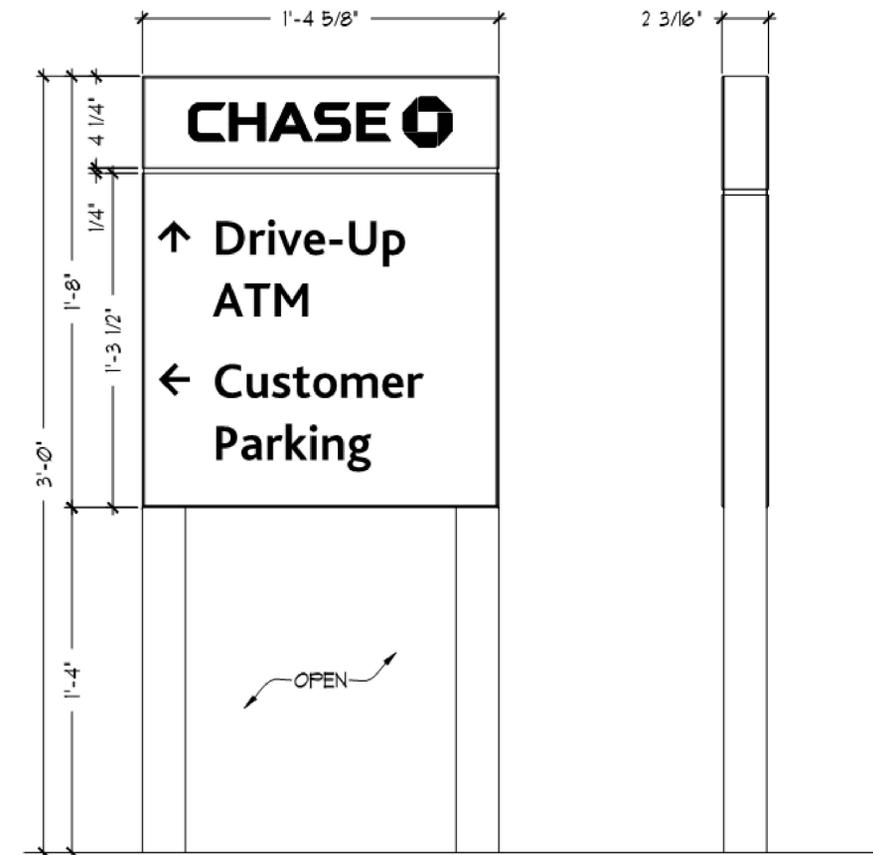

DOCUMENTS PREPARED BY CORE STATES, INC., INCLUDING THIS DOCUMENT, ARE TO BE USED ONLY FOR THE SPECIFIC PROJECT AND SPECIFIC USE FOR WHICH THEY WERE INTENDED. ANY EXTENSION OF USE TO ANY OTHER PROJECTS, BY OWNER OR BY ANY OTHER PARTY, WITHOUT THE EXPRESSED WRITTEN CONSENT OF CORE STATES, INC. IS DONE UNLAWFULLY AND AT THE USER'S OWN RISK. IT IS USED IN A WAY OTHER THAN THAT SPECIFICALLY INTENDED. USER WILL HOLD CORE STATES, INC. HARMLESS FROM ALL CLAIMS AND LOSSES.

CLIENT



Know what's below. Call before you dig. The contractor is specifically cautioned that the location and/or elevation of existing utilities shown on these drawings is based on current information. It is the user's responsibility to verify the location of all utilities before any excavation or construction work is undertaken. CORE STATES, INC. DOES NOT GUARANTEE THE LOCATION OF UTILITIES. THE CONTRACTOR SHALL BE RESPONSIBLE FOR VERIFYING THE LOCATION OF UTILITIES PRIOR TO ANY EXCAVATION OR CONSTRUCTION WORK.

REV	DATE	COMMENT	BY
1	06/01/20	REVISED PER TOWNSHIP COMMENTS	KGF

DOCUMENT SITE PLAN APPROVAL FOR CHASE BANK

SITE LOCATION
MAIN STREET &
BAKER AVENUE
1134 MAIN STREET
CONCORD, MA 01742

ENGINEER SEAL

ALAN D. ROSCOE, P.E.
MA LICENSE #40163
SHEET TITLE
SIGNAGE
DETAILS

JOB #: JPM-27599
DATE: 04/28/2020
SCALE: AS SHOWN
DRAWN BY: CC
CHECKED BY: TP

SHEET NO.
CD-8

